

Job Code 503

ASSEMBLY BUILDING REMODEL


CITY of BERKELEY CORPORATION YARD

1326 Allston Way, Berkeley, California



GENERAL NOTES

1. THESE DRAWINGS ARE A PORTION OF THE CONSTRUCTION DOCUMENTS WITH WHICH THE SPECIFICATIONS ARE INTENDED TO COORDINATE. ANYTHING INDICATED IN ONE AND NOT THE OTHER SHOULD BE EXECUTED AS IF IN BOTH.
2. THE CONTRACTOR SHALL BE FAMILIAR WITH, AND RESPONSIBLE FOR COMPLIANCE WITH ALL APPLICABLE CODES AND BUILDING DEPARTMENT REGULATIONS.
3. DO NOT SCALE THE DRAWINGS.
4. ANY DISCREPANCIES IN THE CONSTRUCTION DOCUMENTS, OR CONFLICTS WITH ACTUAL SITE CONDITIONS SHALL BE BROUGHT TO THE ATTENTION OF THE PROJECT ENGINEER BEFORE PROCEEDING WITH THE WORK.

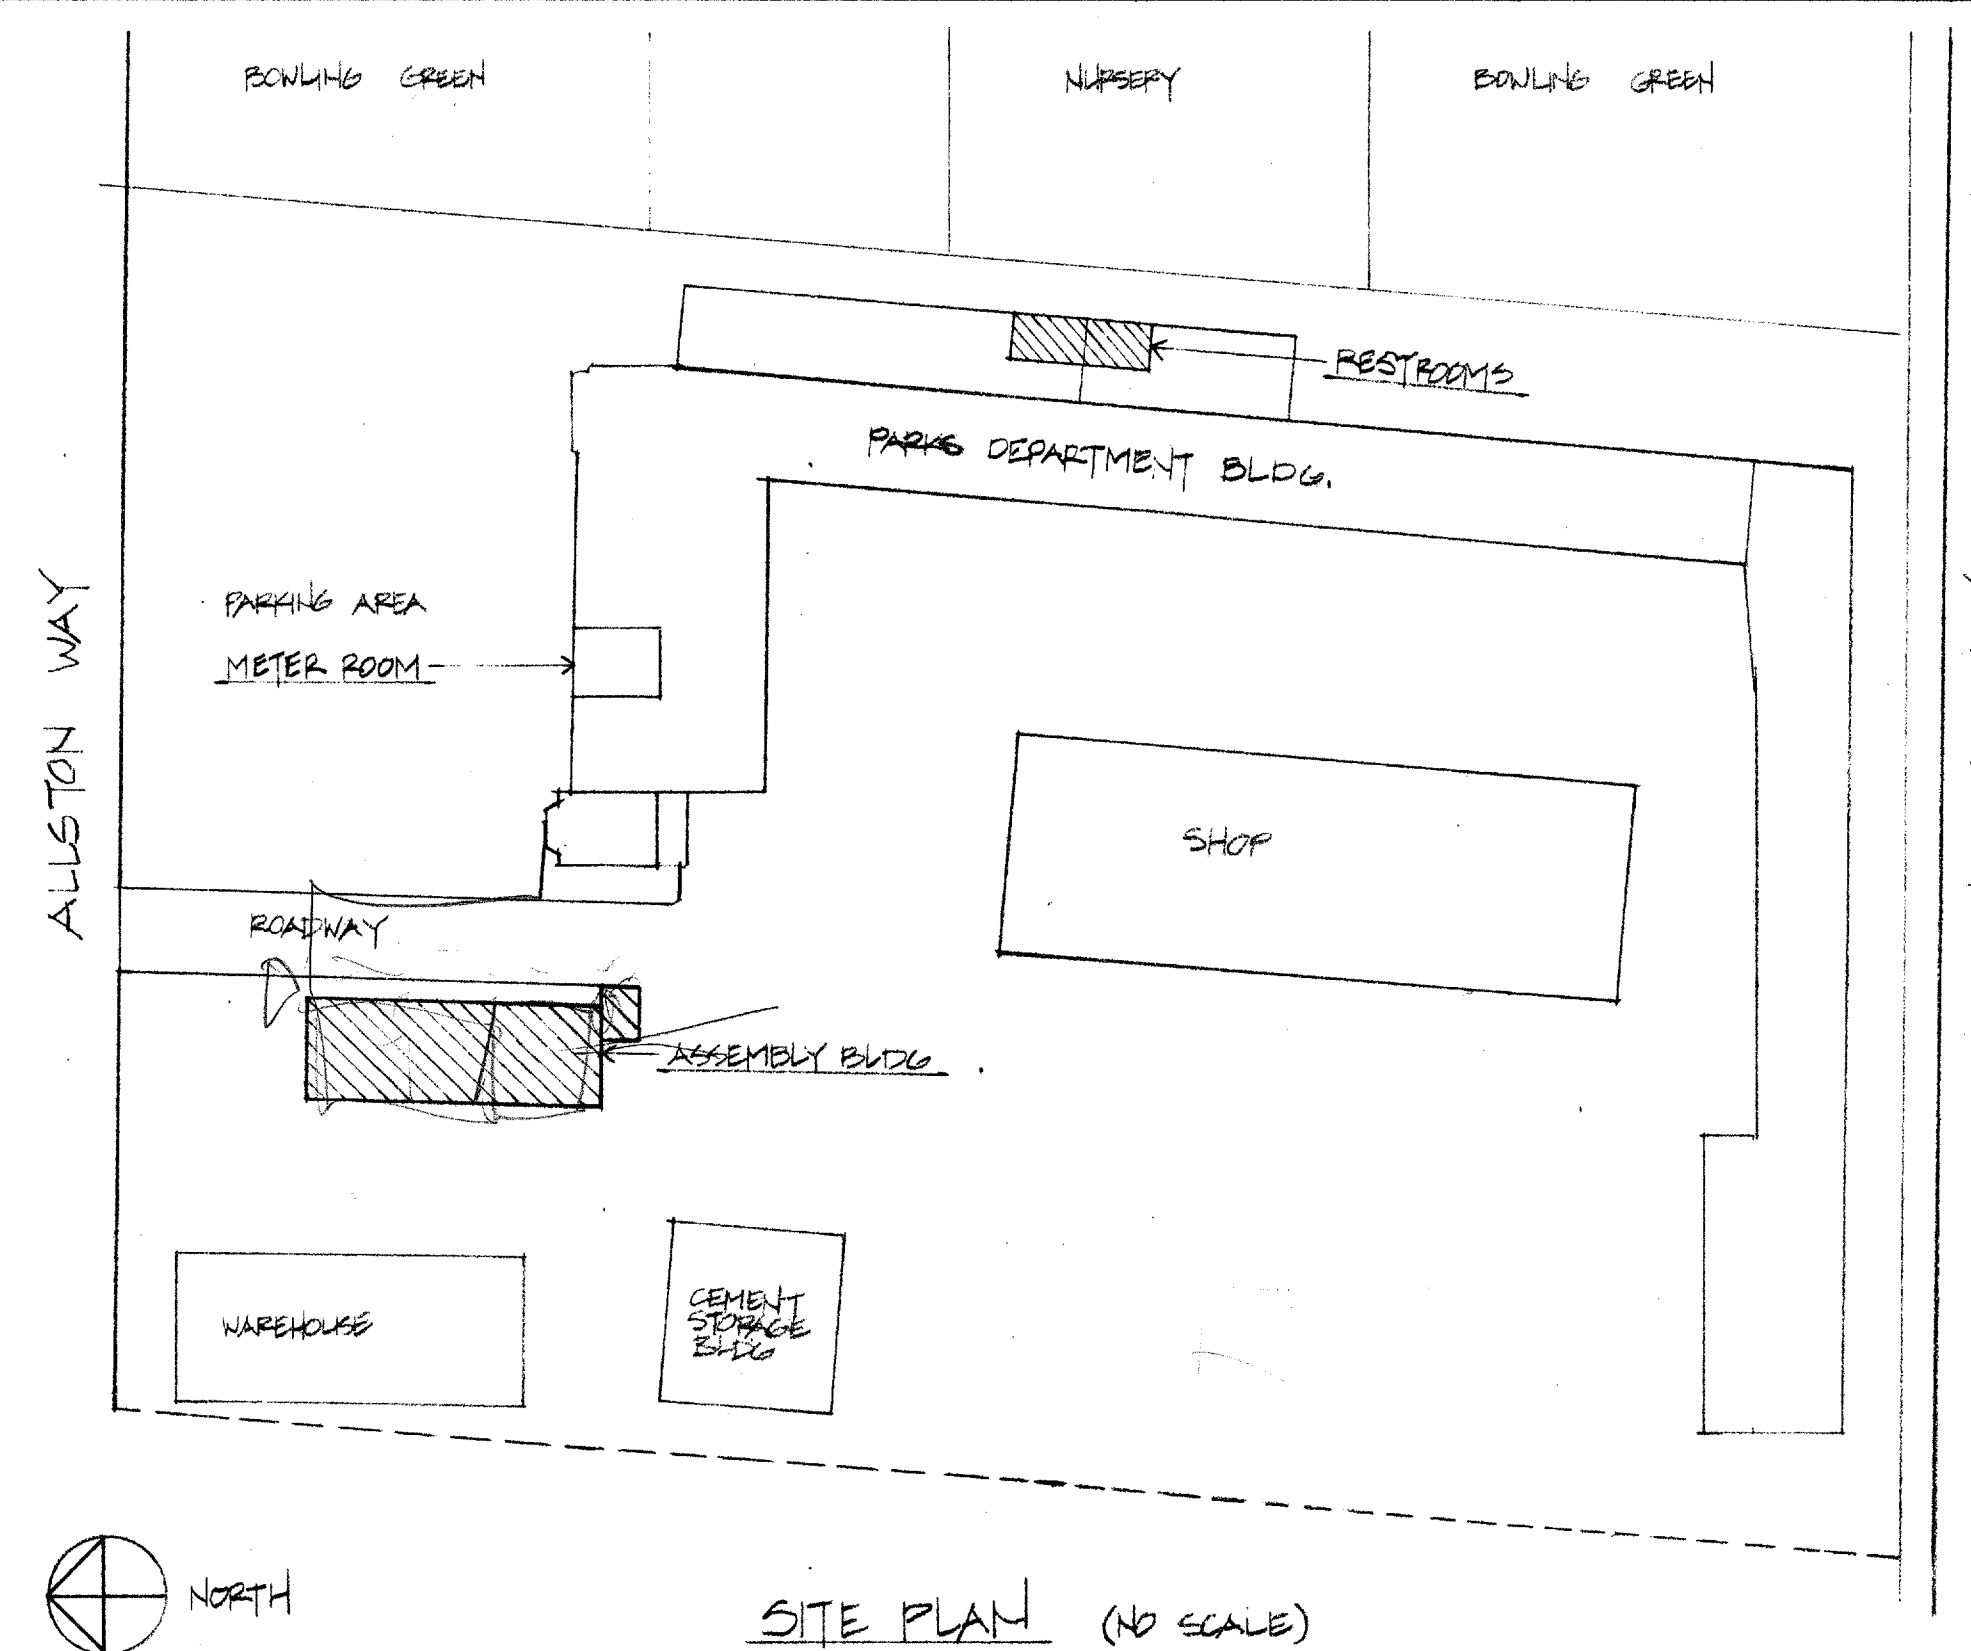


SITE PLAN (NO SCALE)

INDEX OF DRAWINGS

SHEET #	DESCRIPTION
1.	COVER SHEET
2.	FLOOR PLAN - ASSEMBLY BLDG.
3.	WALL / FLOOR MODIFICATION PLAN
4.	EXTERIOR ELEVATIONS & SECTION
5.	INTERIOR ELEVATIONS
6.	DOOR, WINDOW & FINISH SCHEDULES
7.	DETAILS
8.	REFLECTED CEILING PLAN & ELECTRICAL PLAN
9.	PLUMBING PLAN & FIXTURE SCHEDULES
10.	MECHANICAL PLAN
11.	FLOOR PLANS - PARKS DEPARTMENT BUILDING
12.	INTERIOR ELEVATIONS & DOOR/FINISH/LIGHTING SCHEDULES
13.	MECHANICAL PLAN - PARKS DEPT. BLDG.
14.	FIXTURE SCHEDULES - PARKS DEPT. BLDG.


REVISIONS	BY

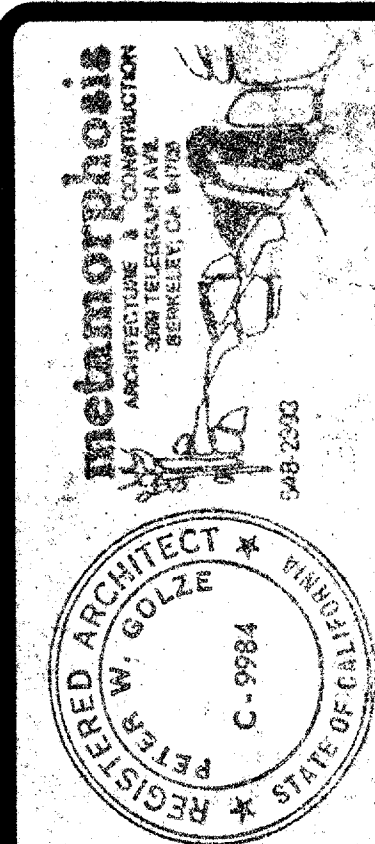

COVER SHEET

ASSEMBLY BUILDING REMODEL
CITY of BERKELEY CORPORATION YARD
1326 Allston Way, Berkeley, California

DRAWN D.V.
CHECKED P.G.
DATE 12-6-85
SCALE
JOB NO. 8515
SHEET 1
OF 14 SHEETS

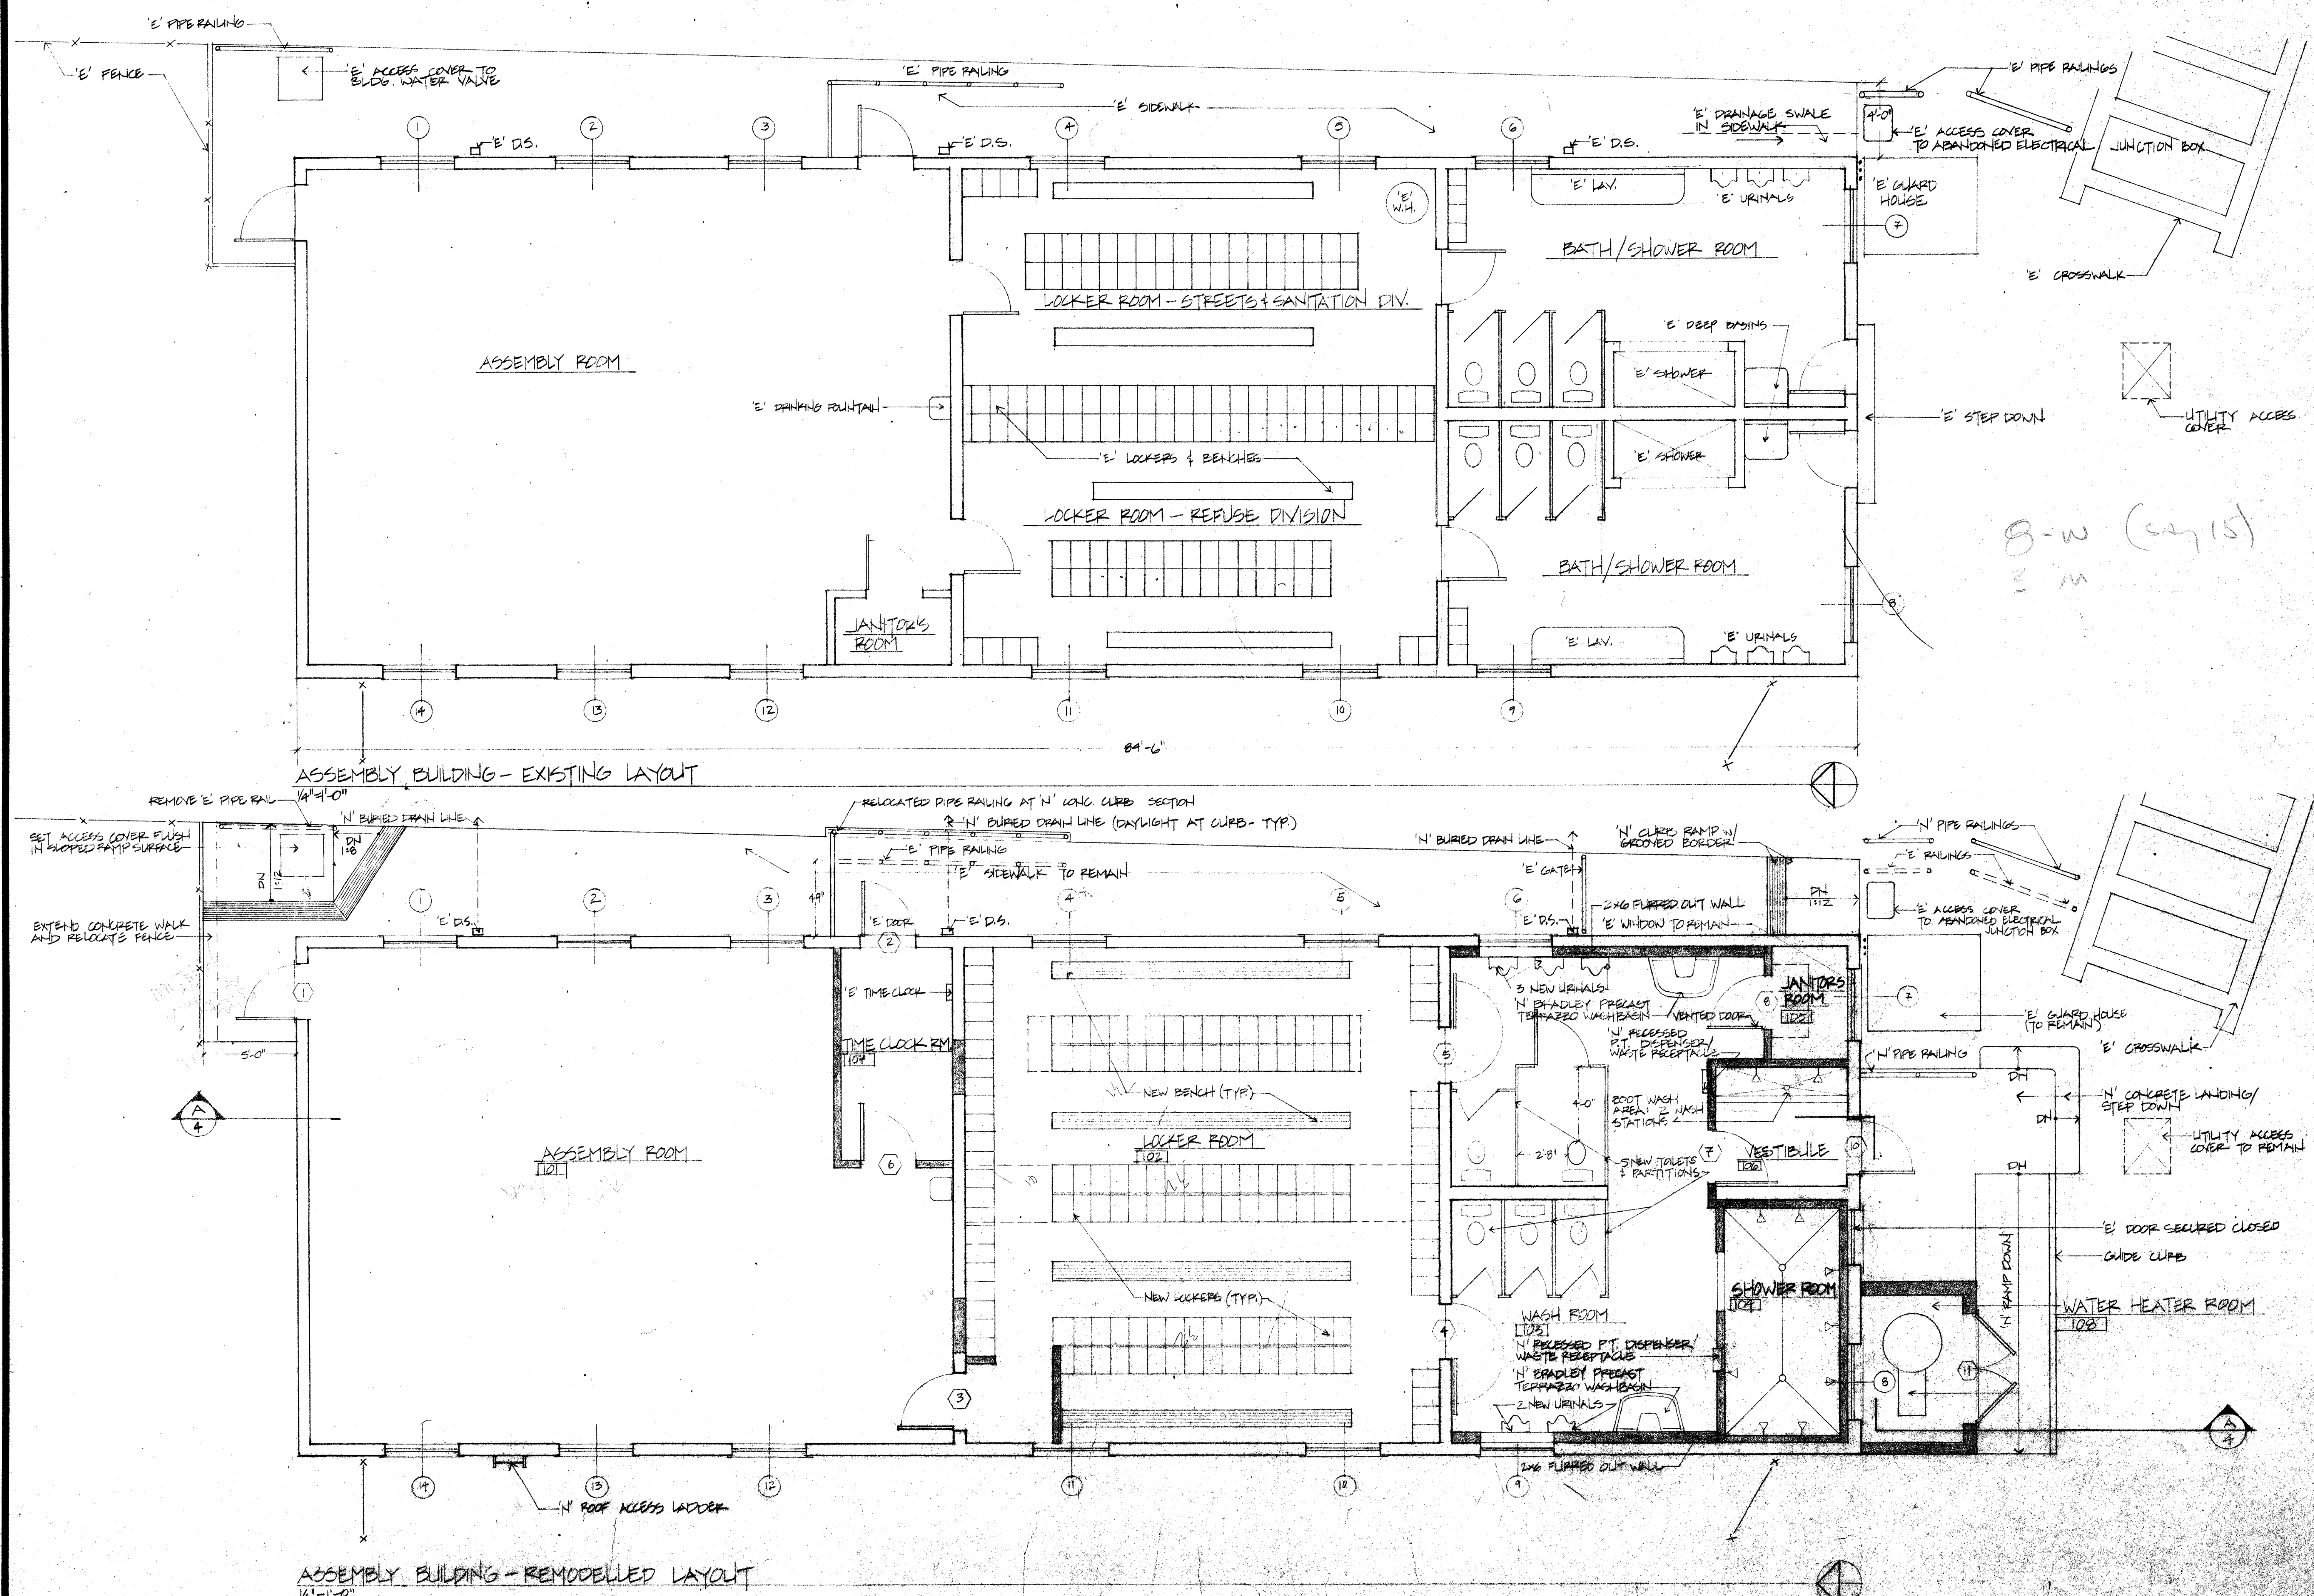

REVISIONS	BY

metamorphosis

ARCHITECTS

1326 ALISTON WAY, BERKELEY, CA 94704

PHOTOGRAPH BY JAMES H. HARRIS

REGISTERED ARCHITECT

PELTON W. GILZE

C-9984

STATE OF CALIFORNIA


FLOOR PLAN - ASSEMBLY BUILDING

ASSEMBLY BUILDING REMODEL


CITY OF BERKELEY CORPORATION YARD

1326 Aliston Way, Berkeley, California


DRAWN	P.V.
CHECKED	P.G.
DATE	12-6-85
SCALE	1/4" = 1'-0"
JOB NO.	8818
SHEET	2
OF 14 SHEETS	

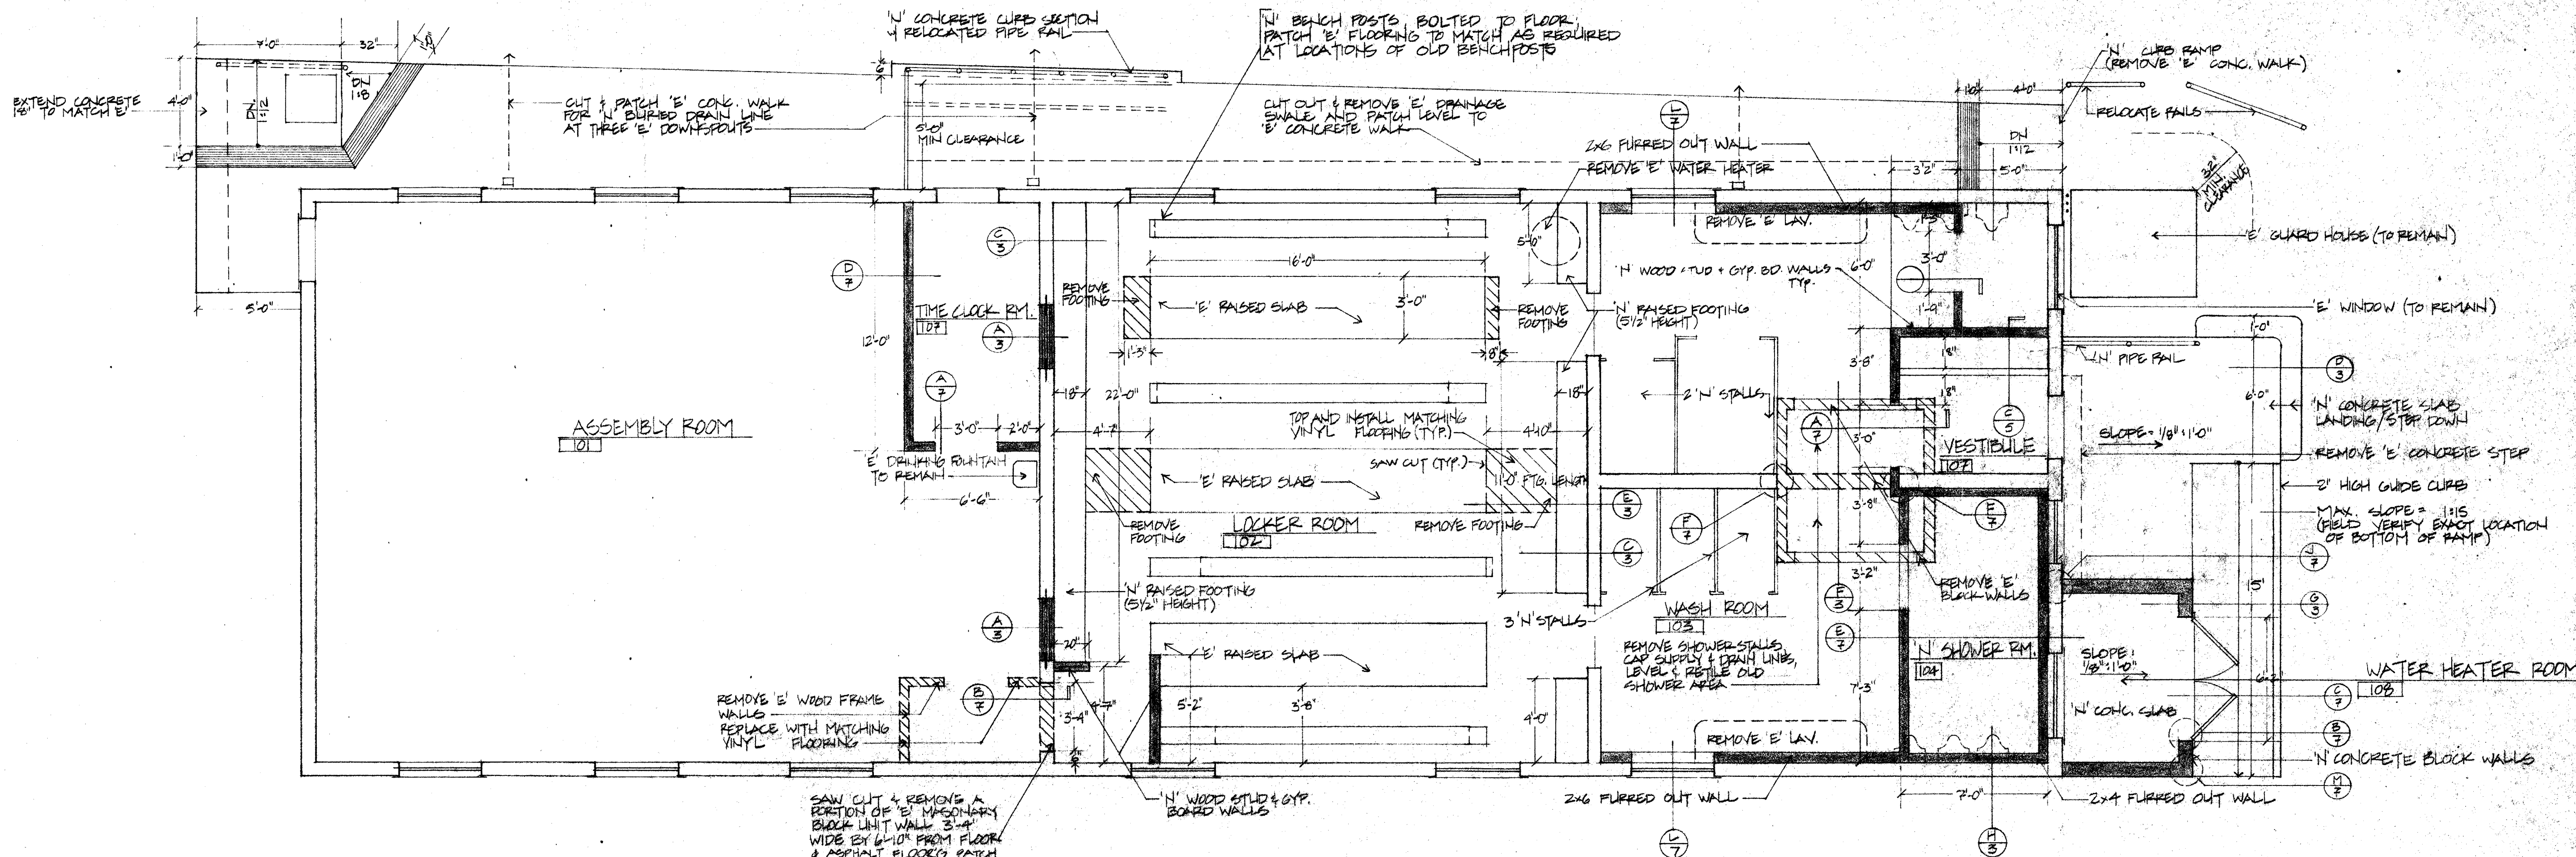

ASSEMBLY BUILDING - FLOOR/WALL MODIFICATION PLAN
1/4" = 1'-0"

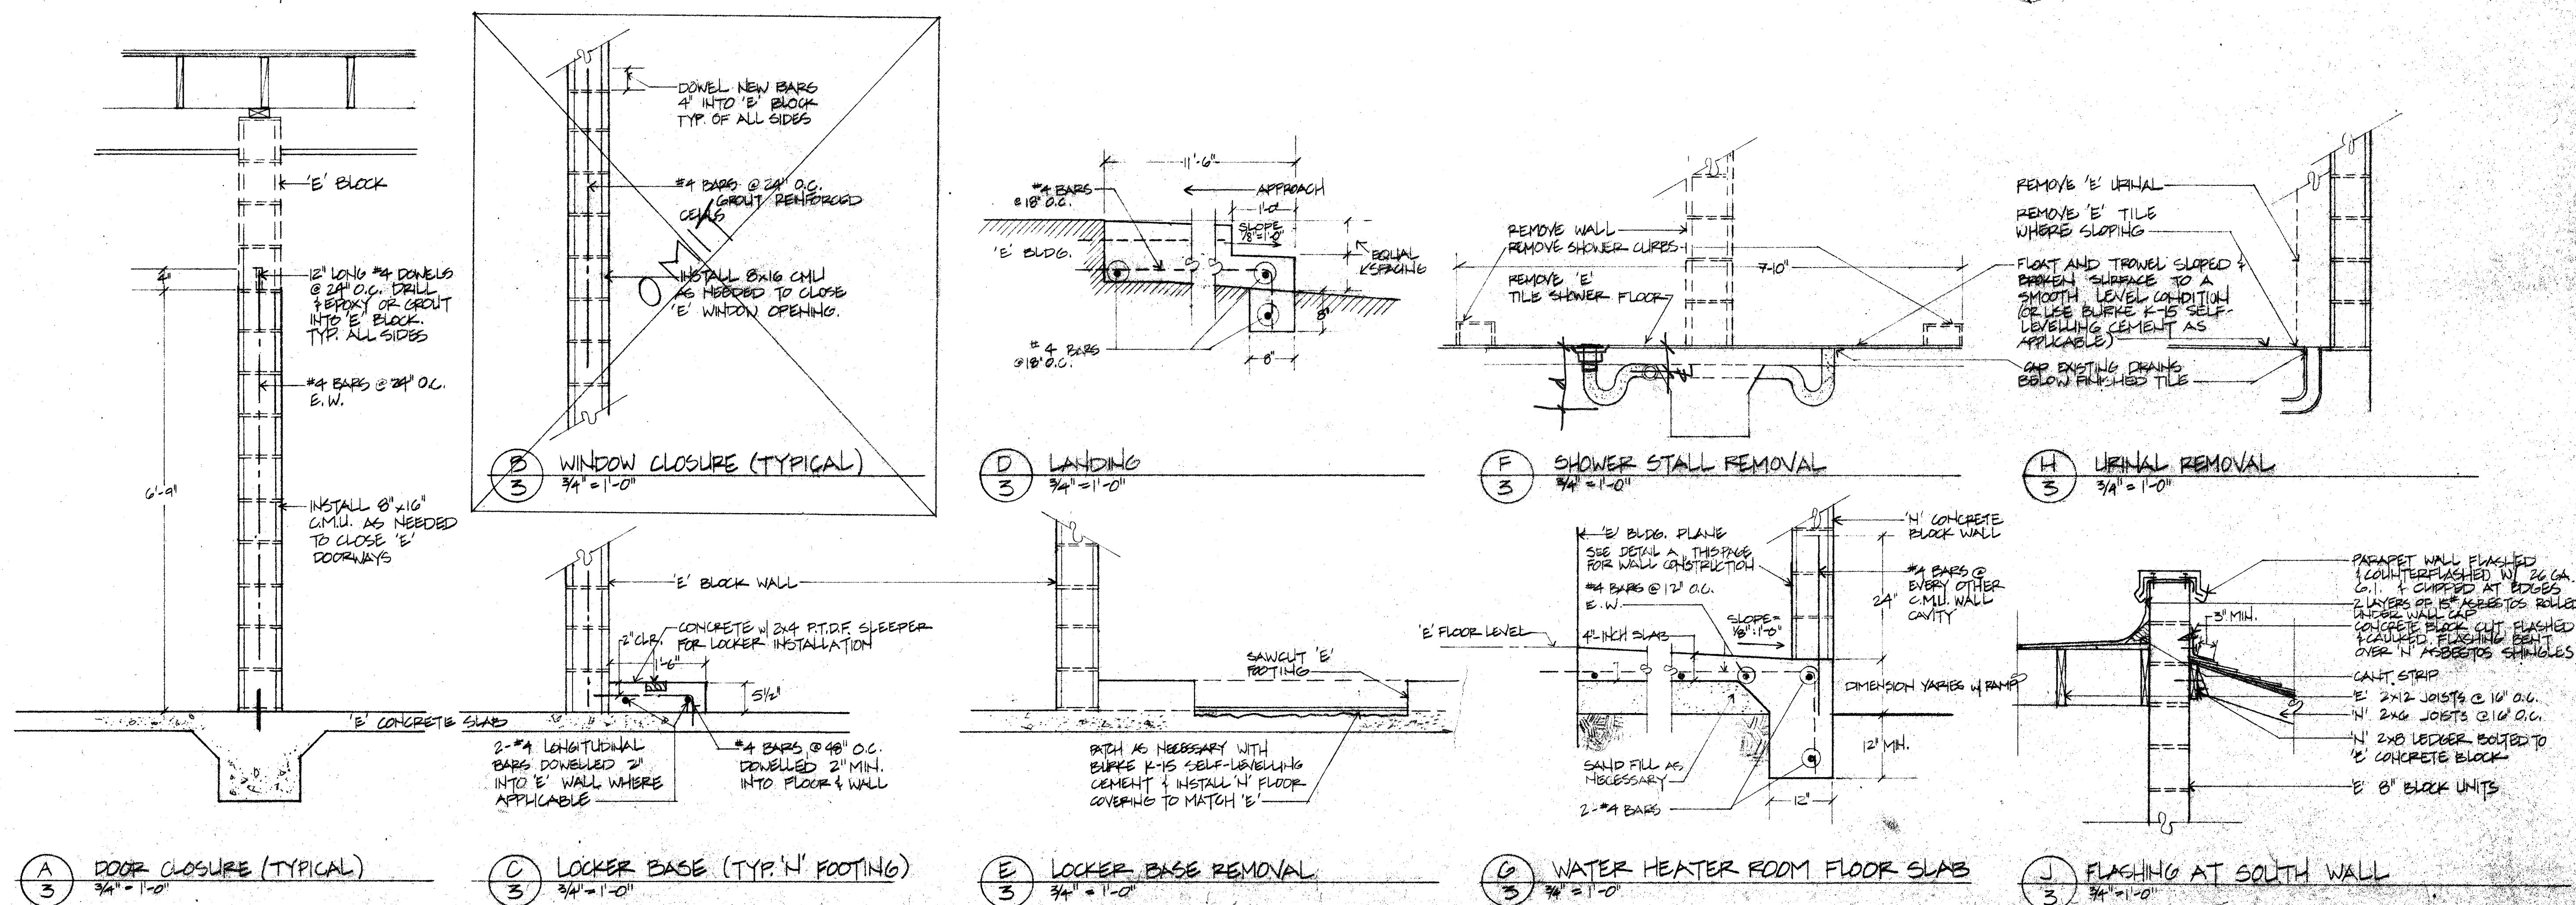


REVISIONS	BY
RELOCATE WATER HEATER RM. 11-85	DN

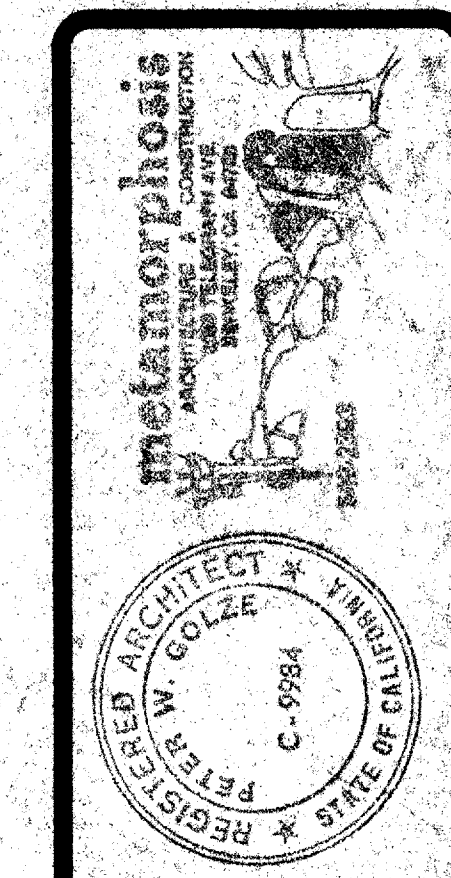

WALL/FLOOR MODIFICATION PLAN


ASSEMBLY BUILDING REMODEL
CITY OF BERKELEY CORPORATION YARD
1326 Allston Way, Berkeley, California

DRAWN DN
CHECKED P.G.
DATE 12-6-85
SCALE AS NOTED
JOB NO. 0815
SHEET 3
OF 14 SHEETS

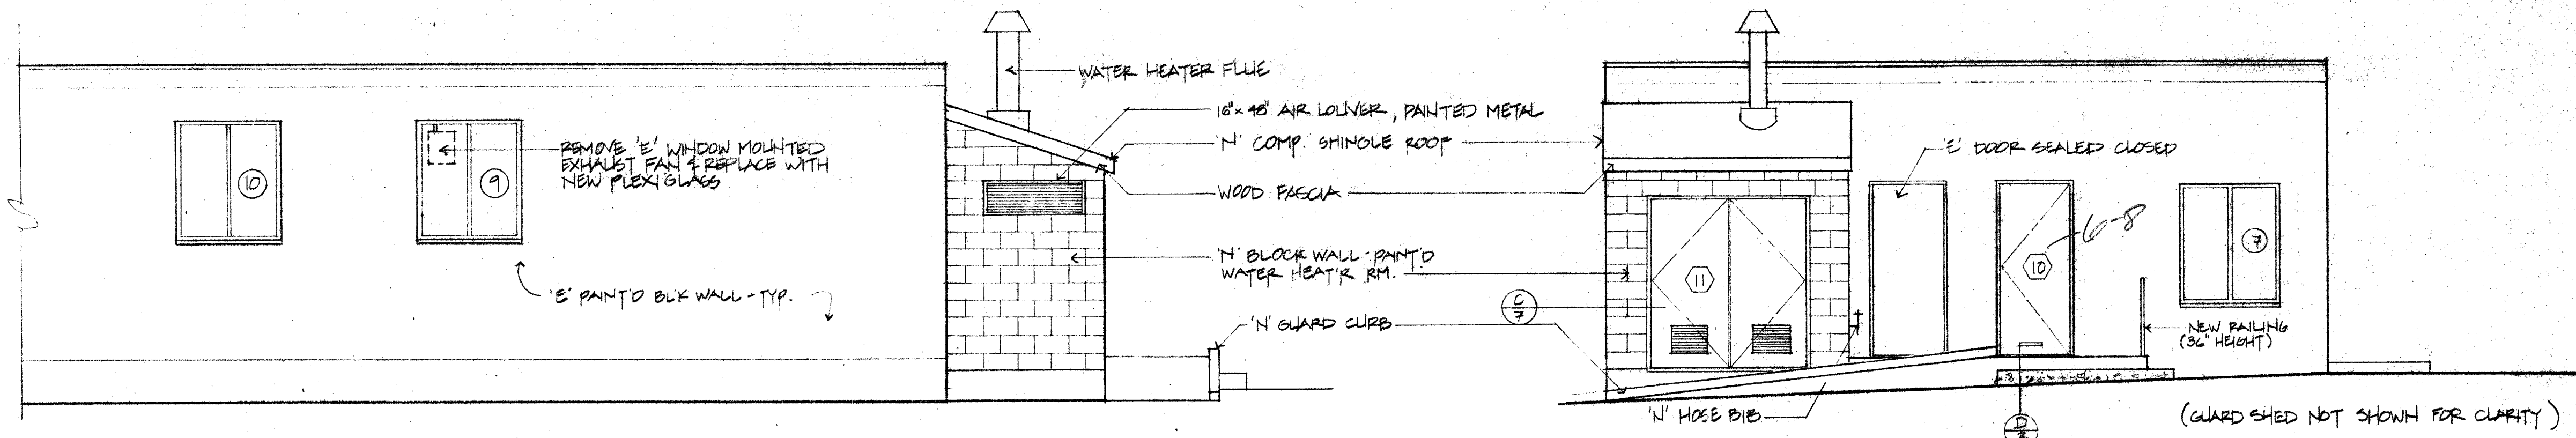


PARTIAL WEST ELEVATION
1/4" = 1'-0"


SOUTH ELEVATION
1/4" = 1'-0"

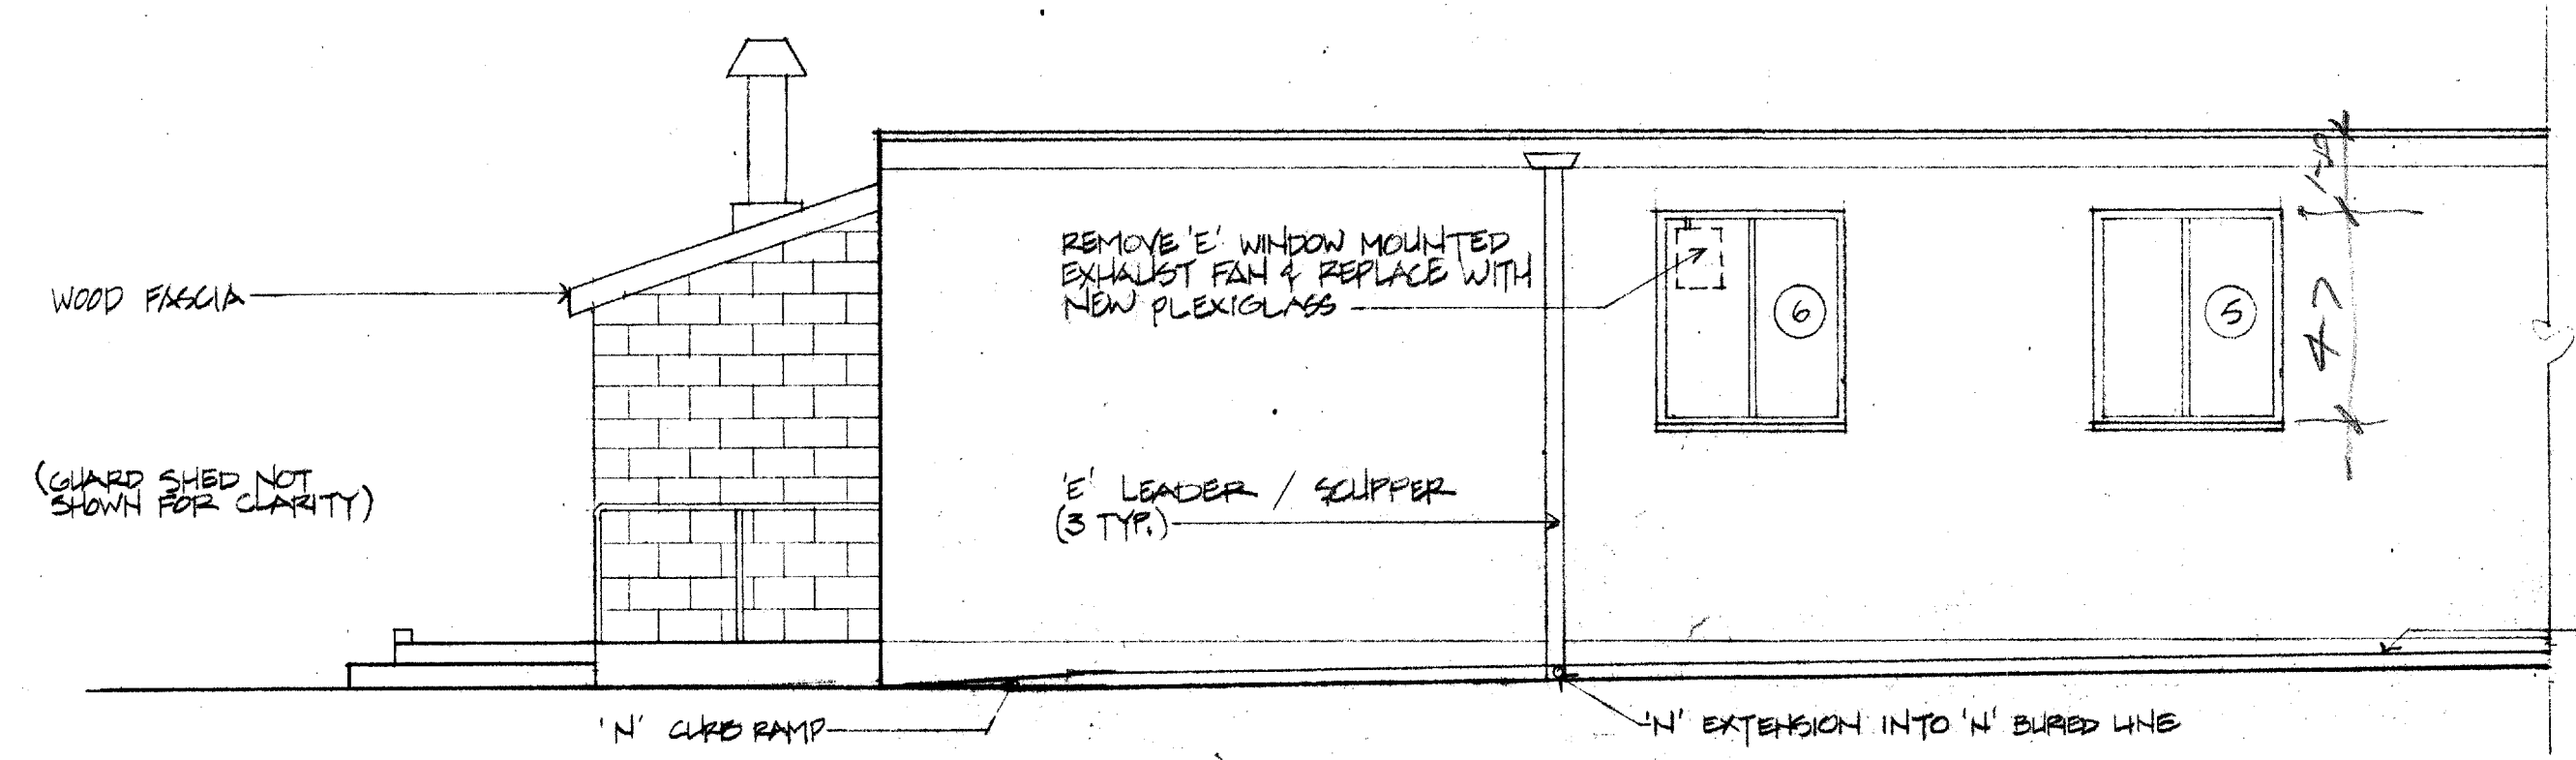


PARTIAL EAST ELEVATION
1/4" = 1'-0"

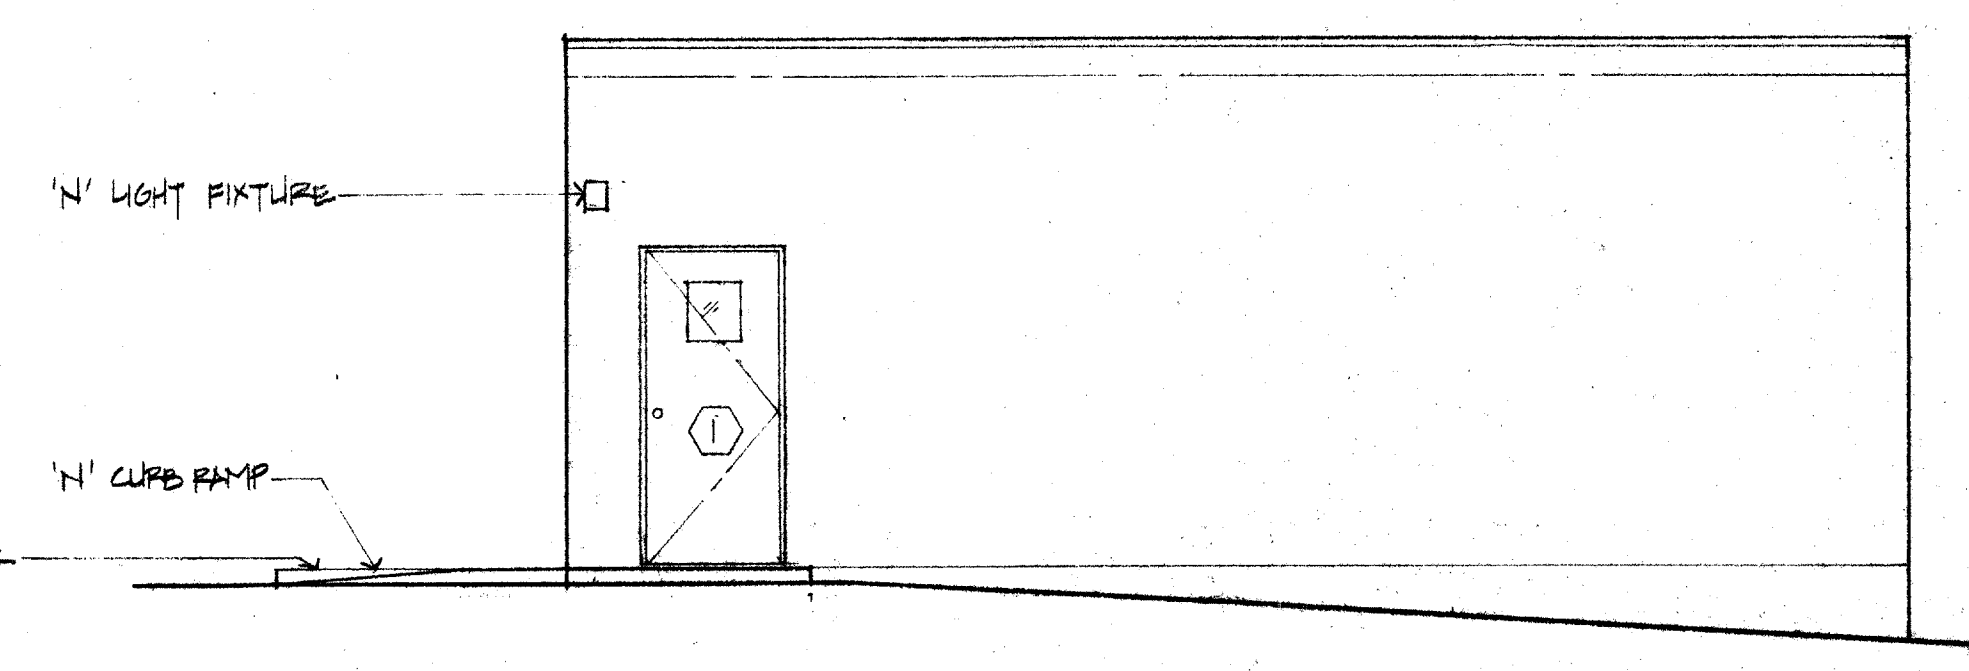

NORTH ELEVATION
1/4" = 1'-0"

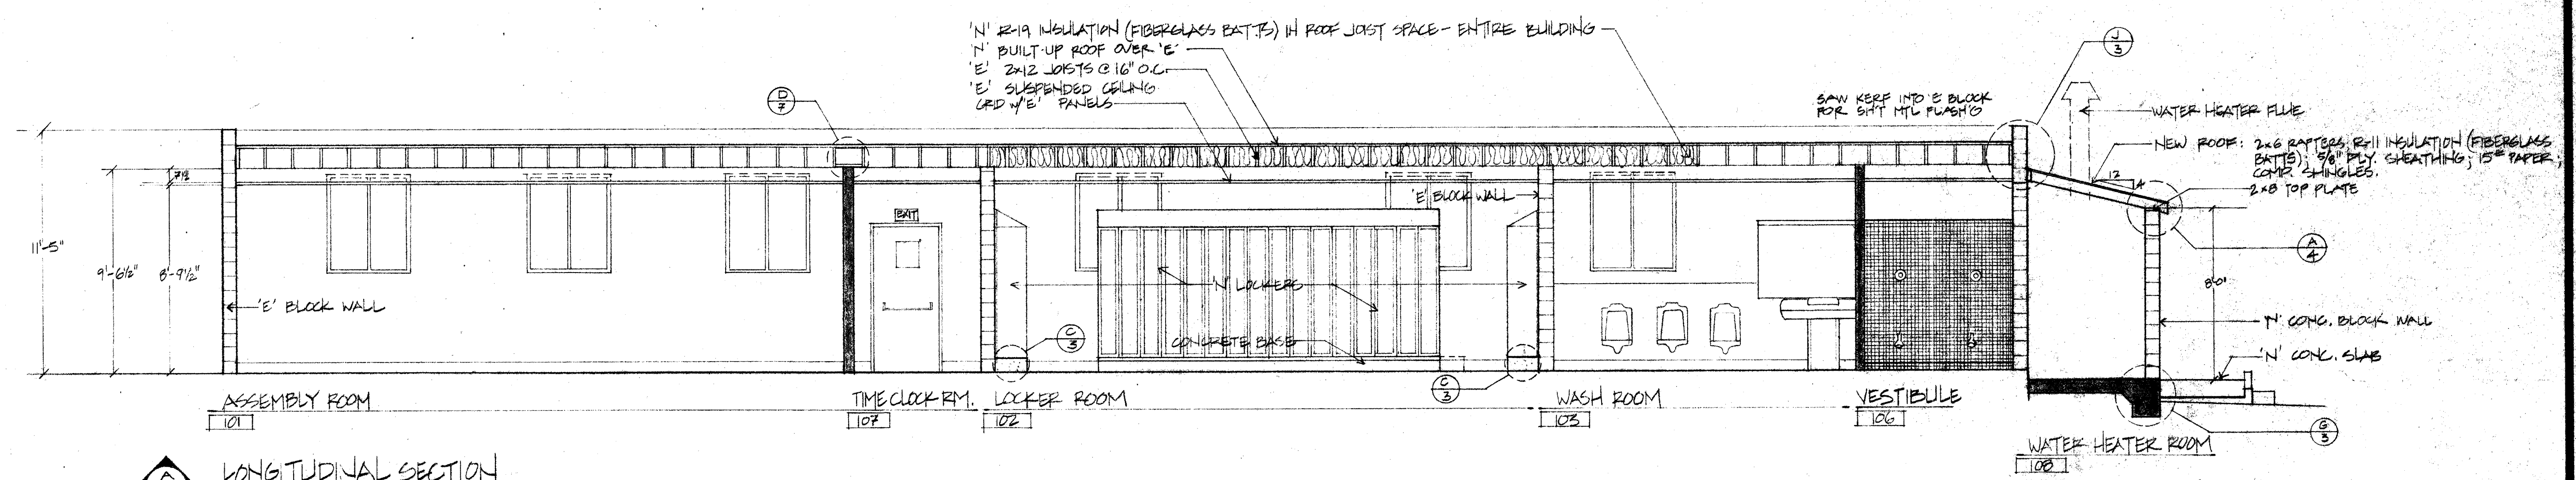


LONGITUDINAL SECTION
1/4" = 1'-0"

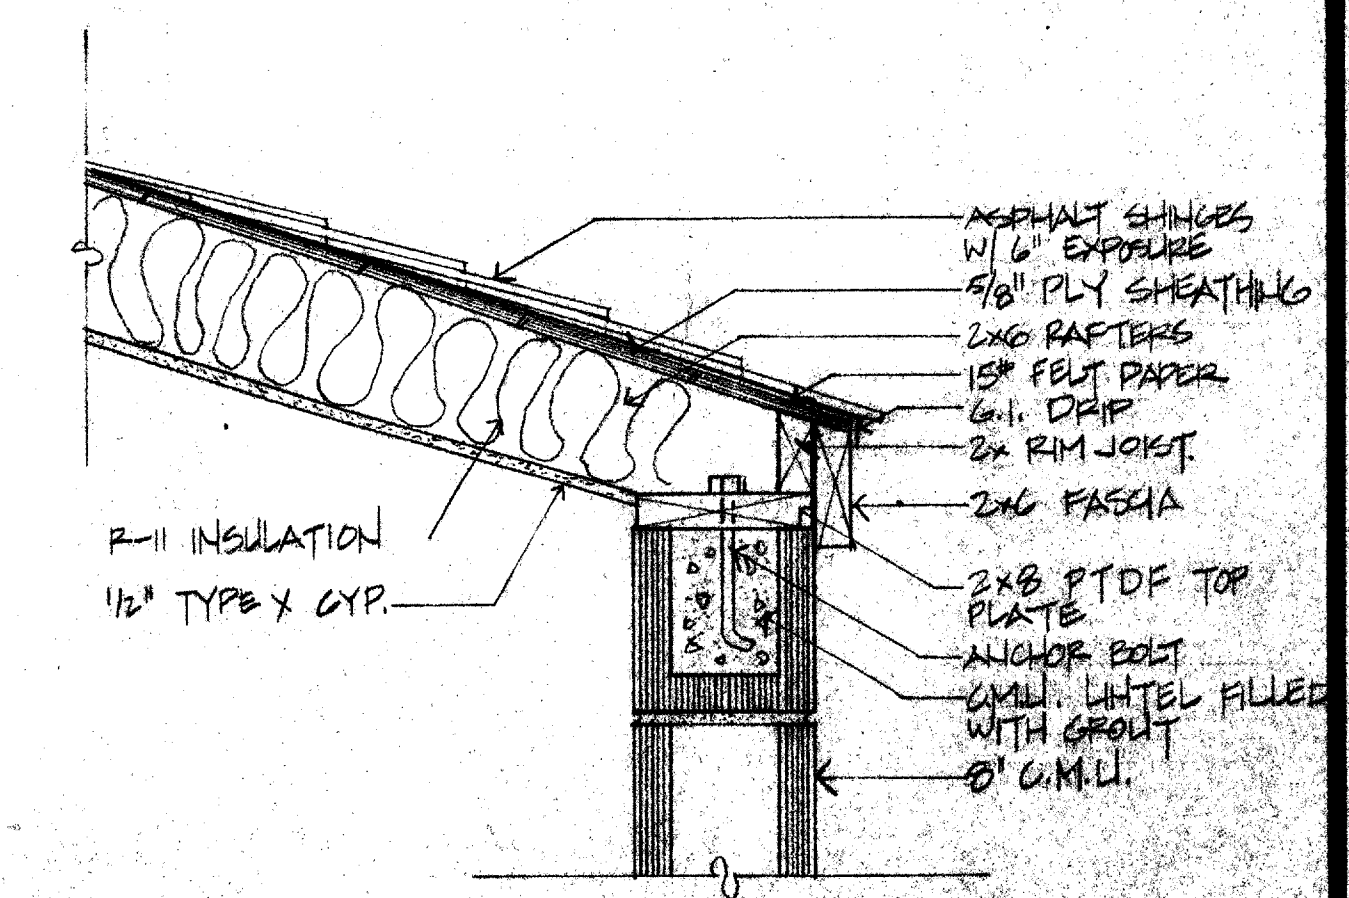

NEW ROOF AT MASONRY WALL
1/2" = 1'-0"


















REVISIONS	BY

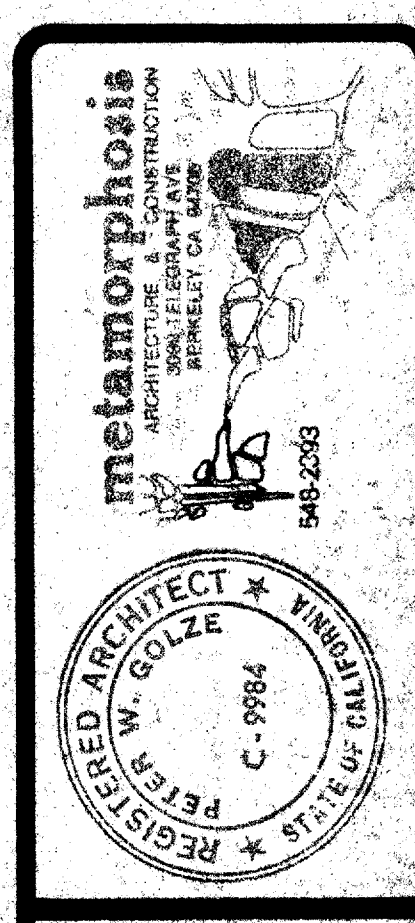


EXTERIOR ELEVATIONS & SECTION

ASSEMBLY BUILDING REMODEL
CITY OF BERKELEY CORPORATION YARD
1326 Allston Way, Berkeley, California

DRAWN D.V.
CHECKED P.G.
DATE 12-6-89
SCALE AS NOTED
JOB NO. 8515
SHEET 4
OF 14 SHEETS

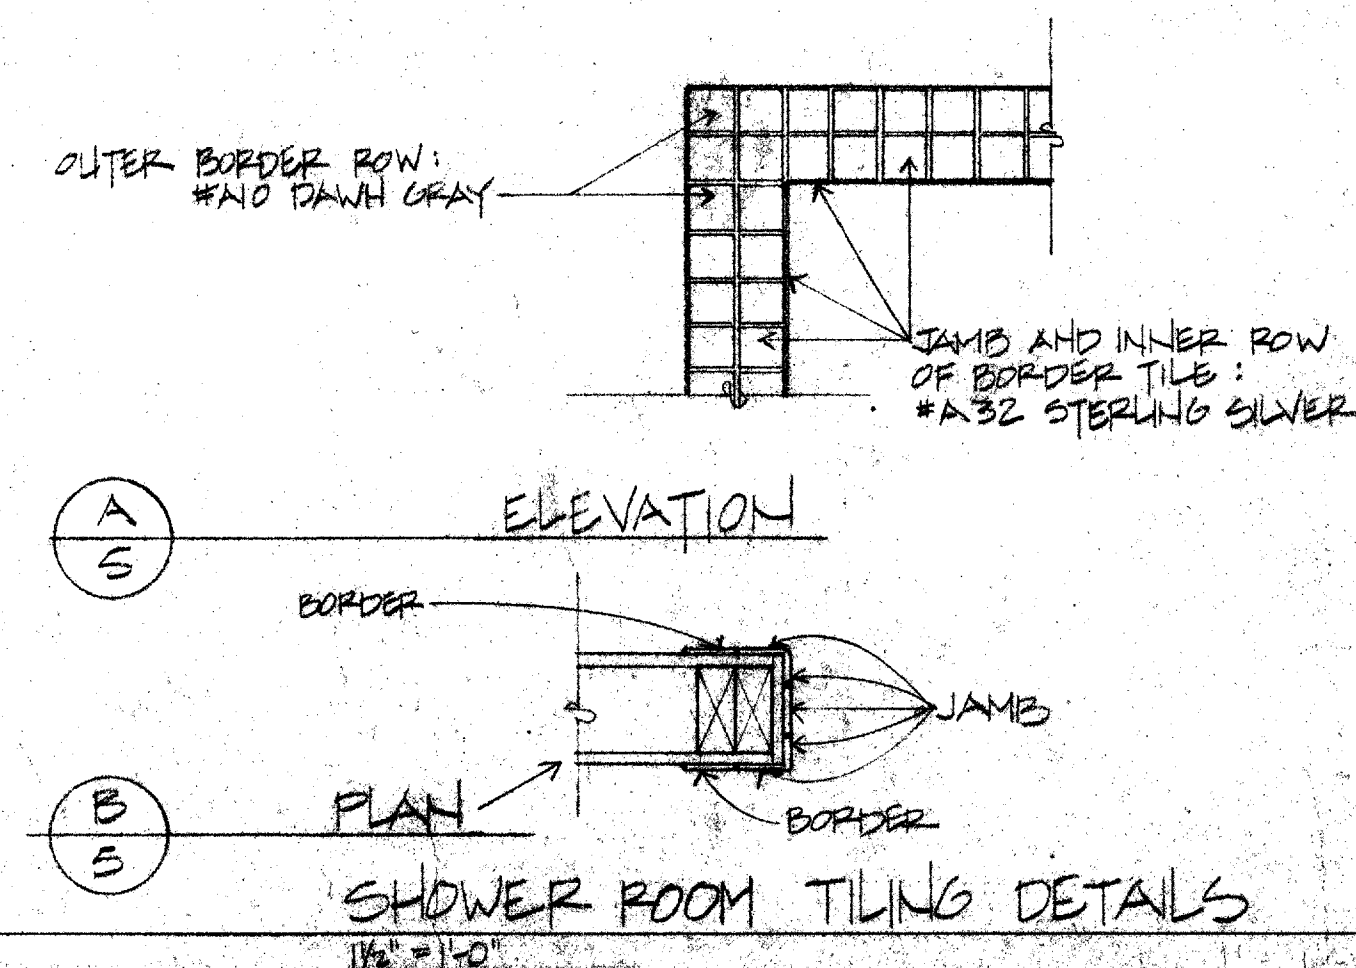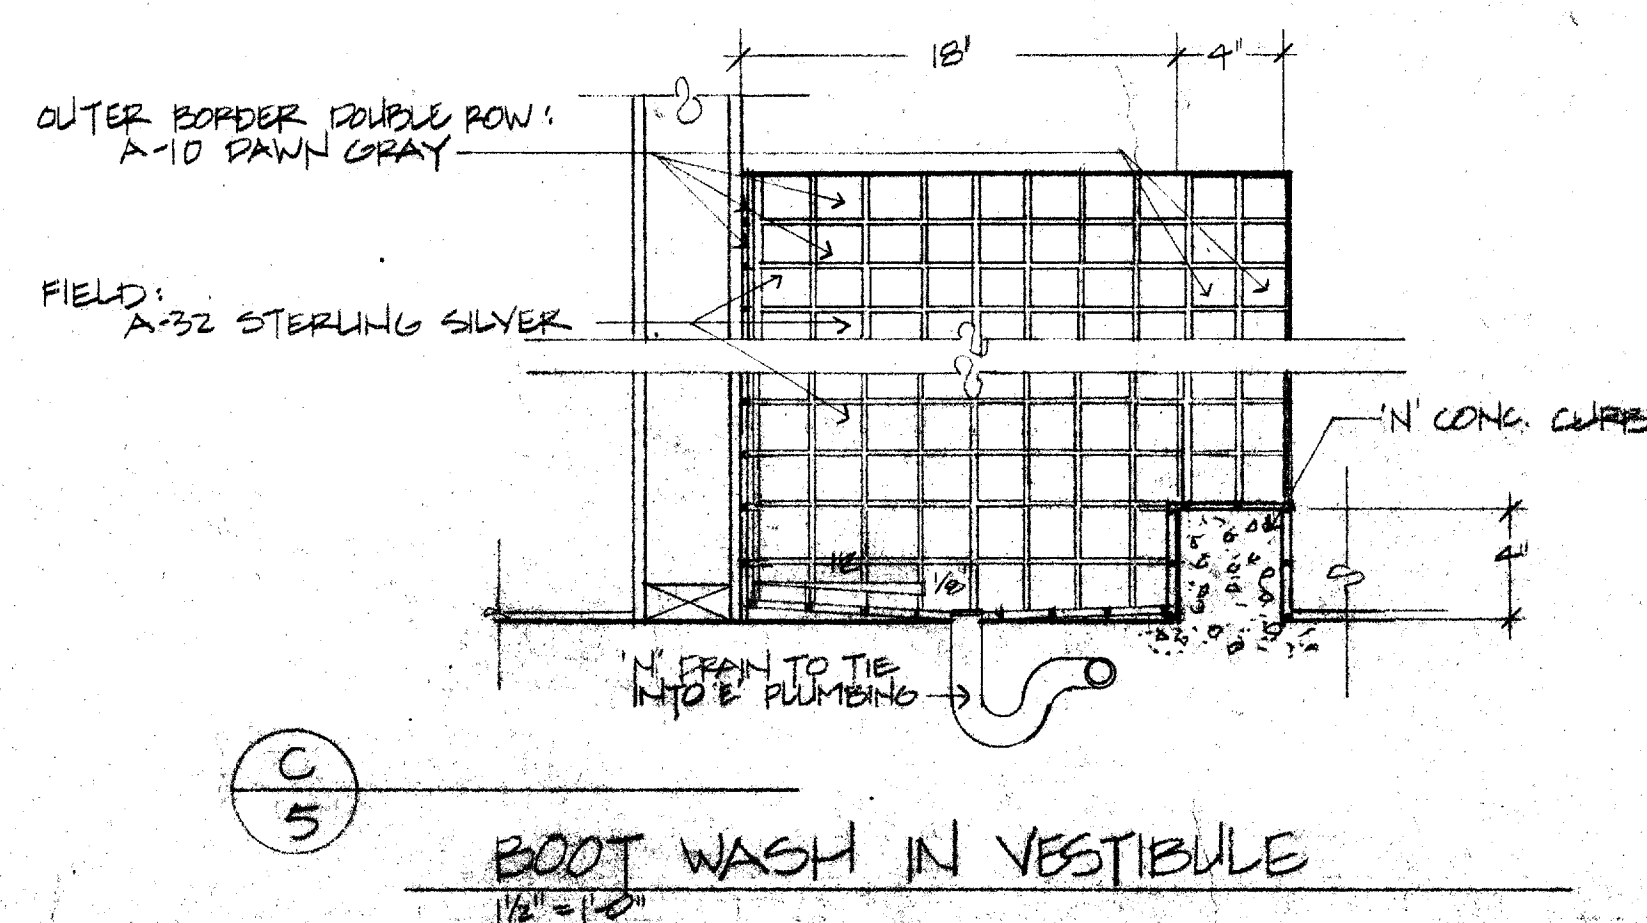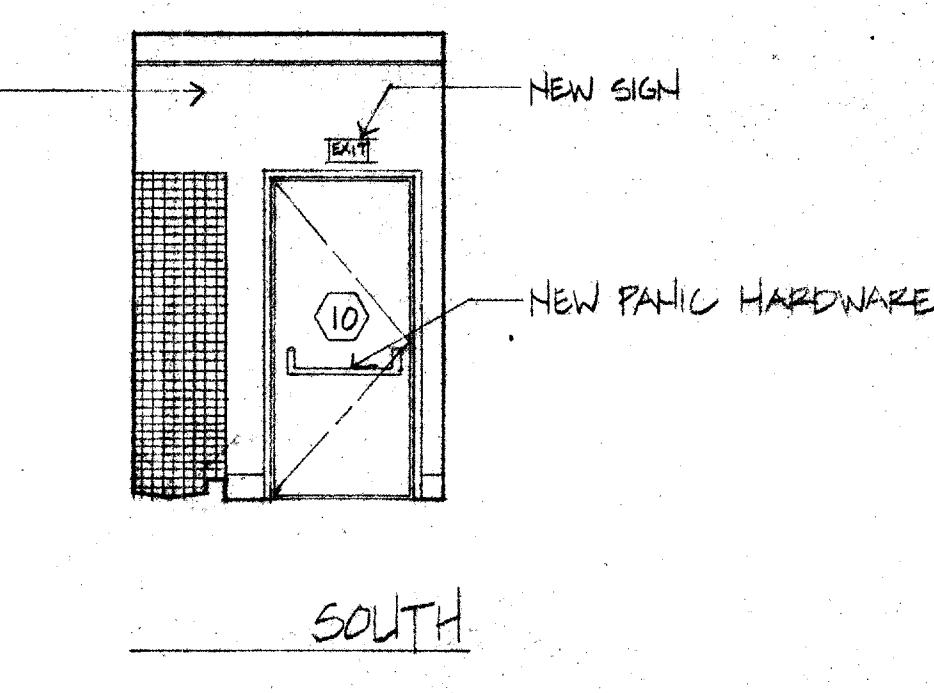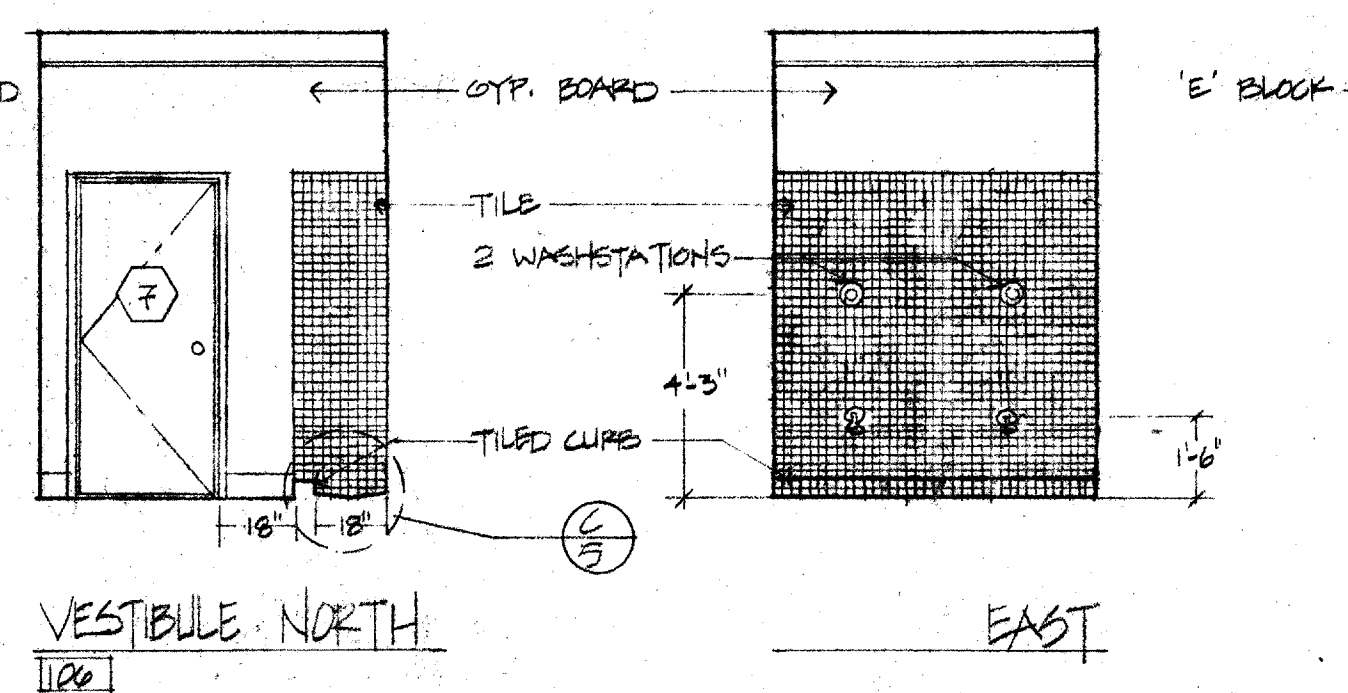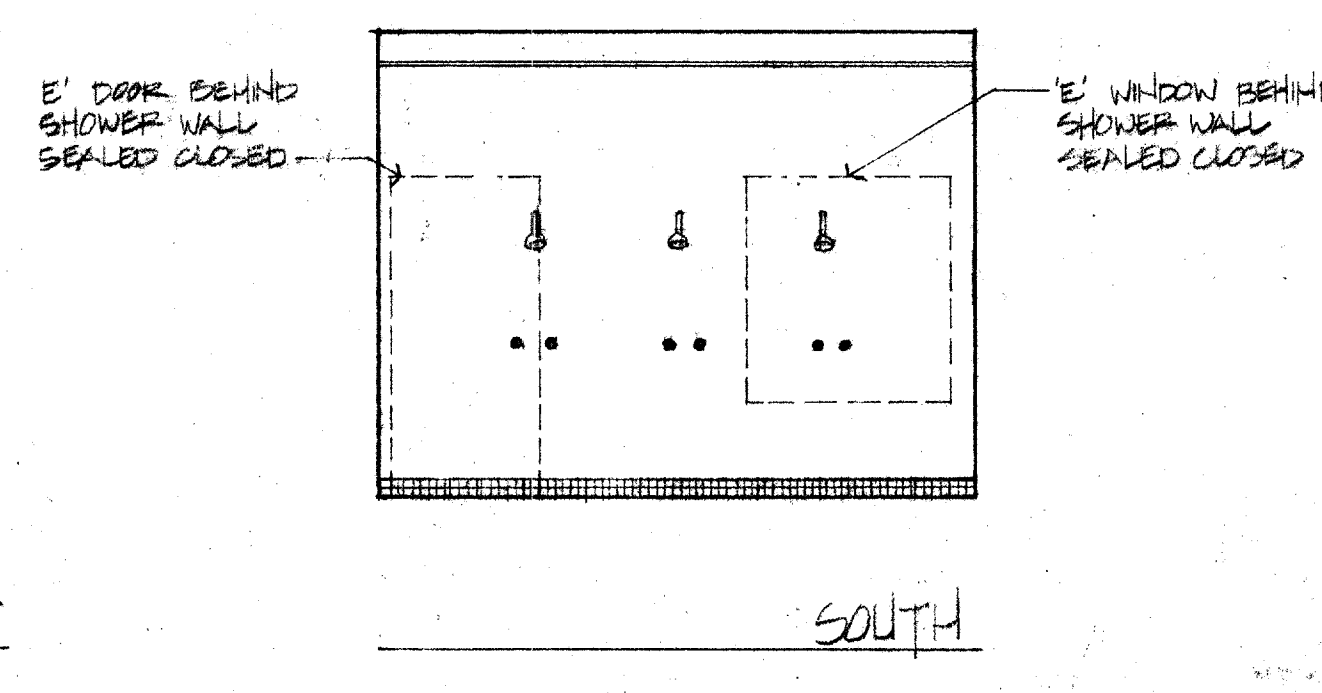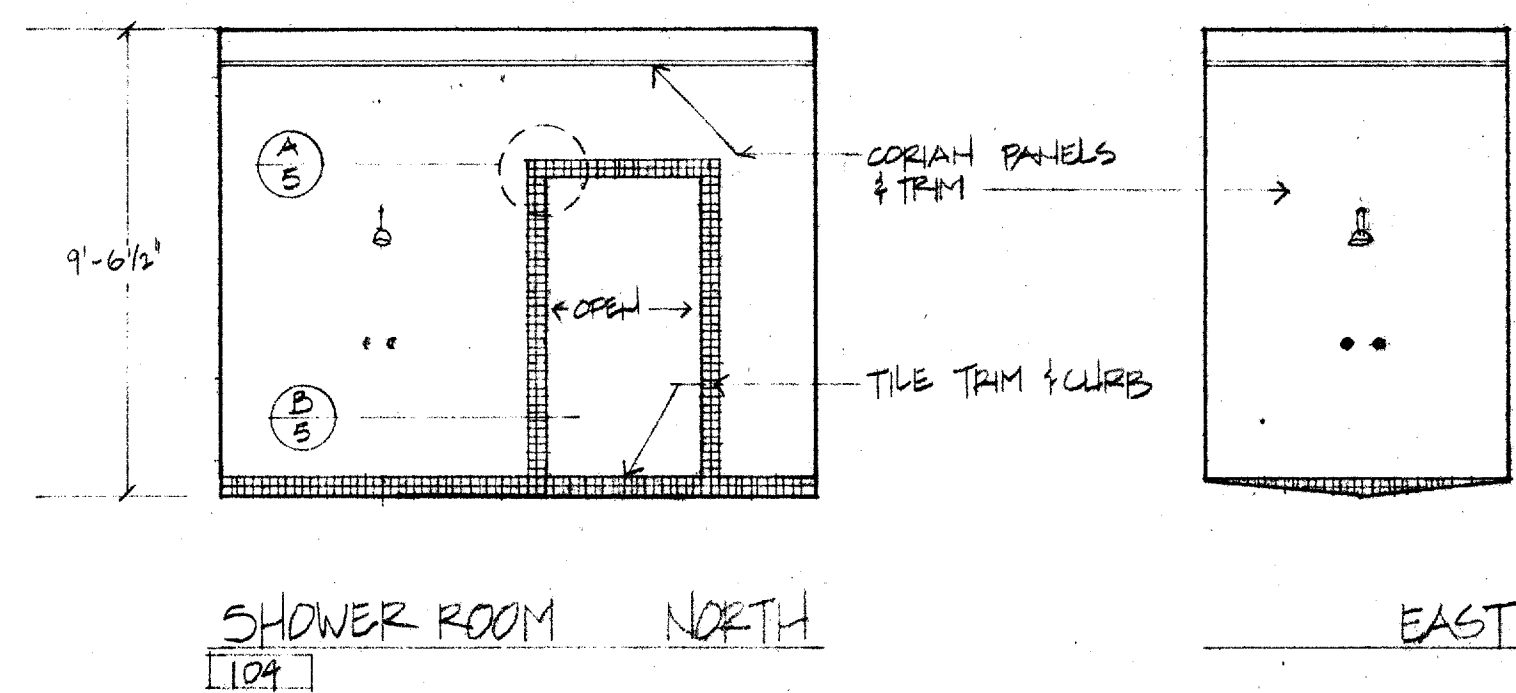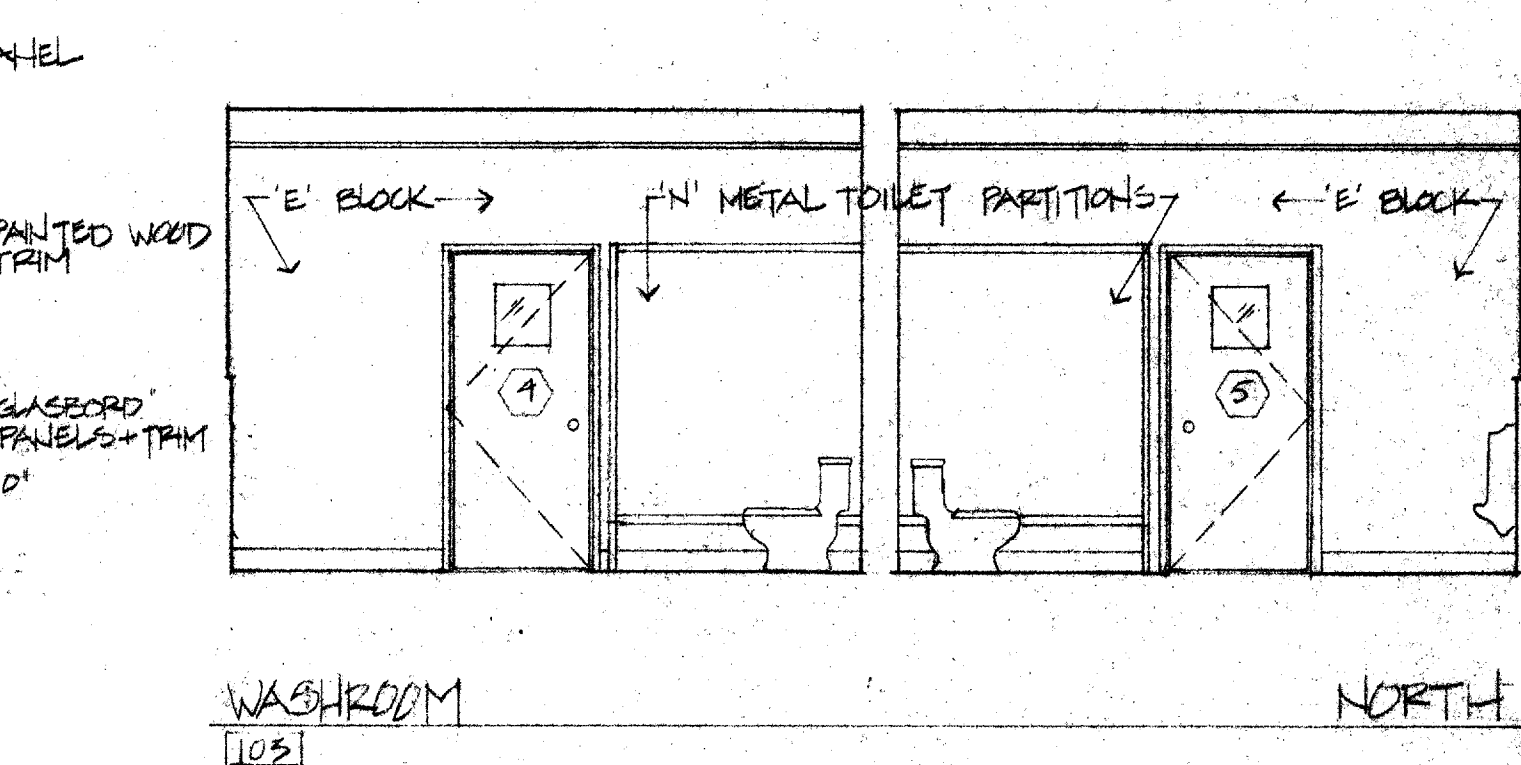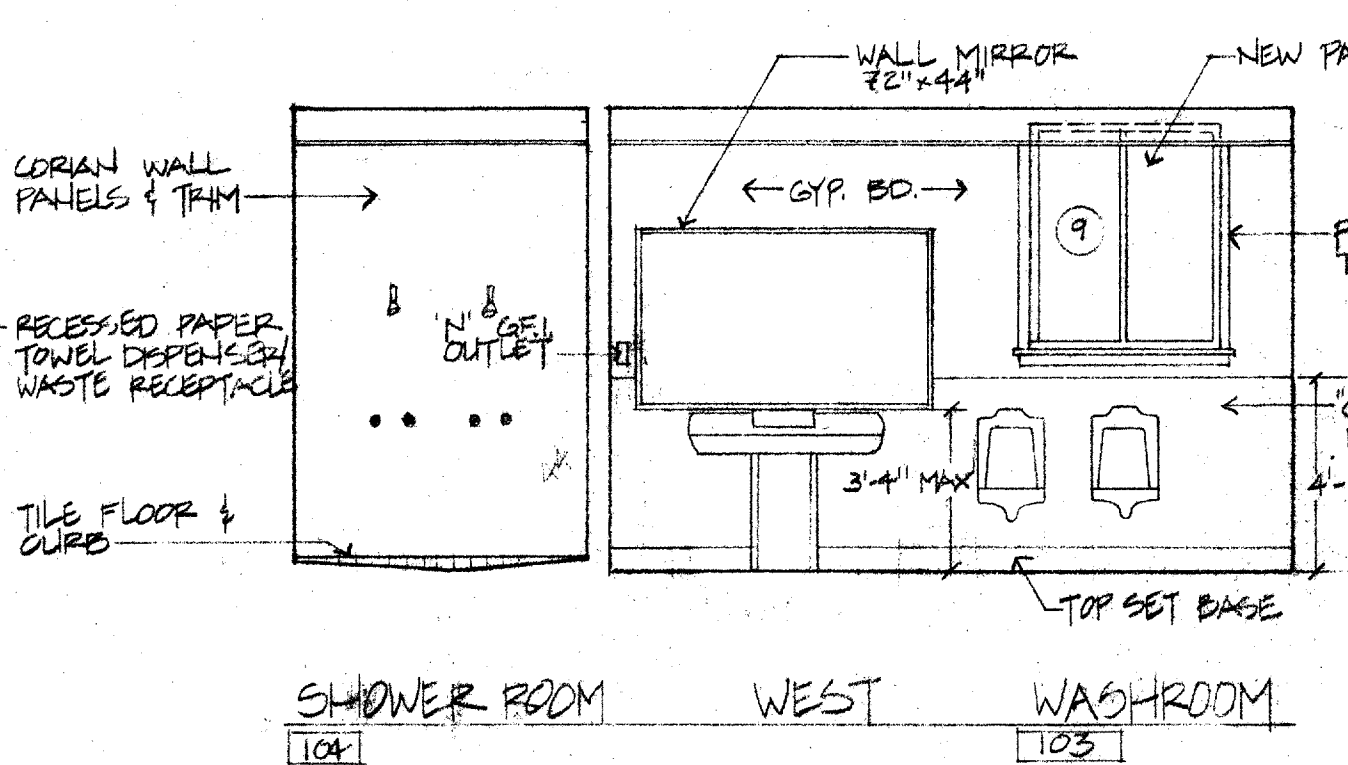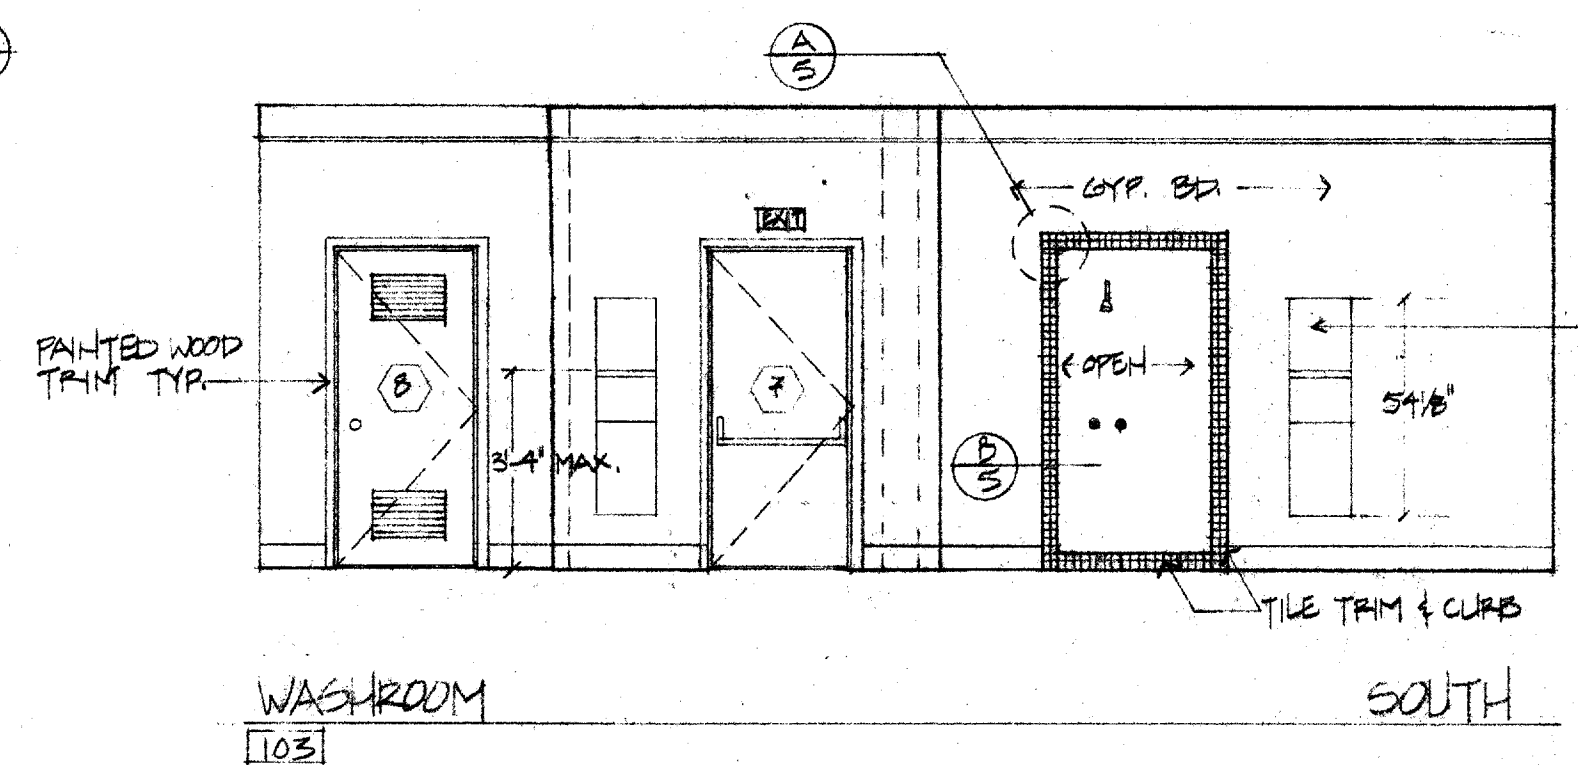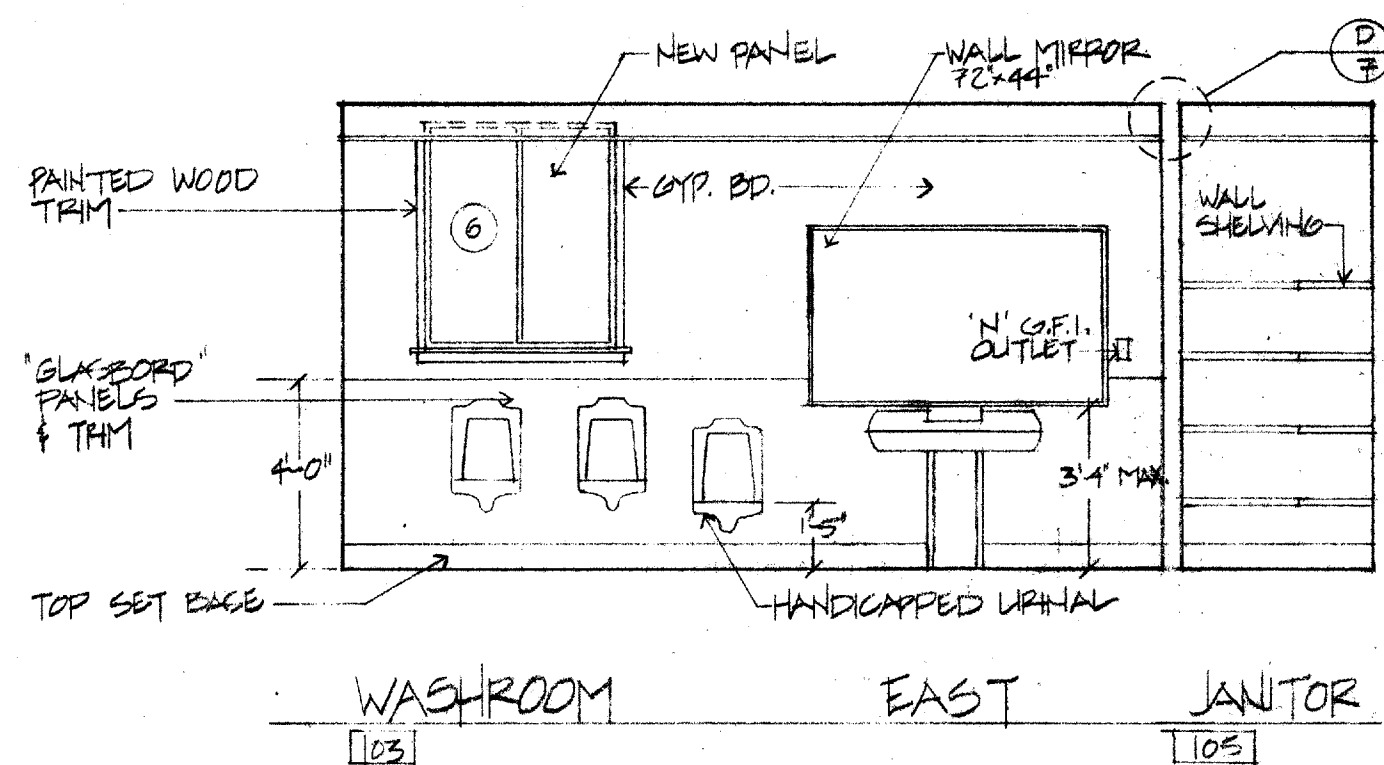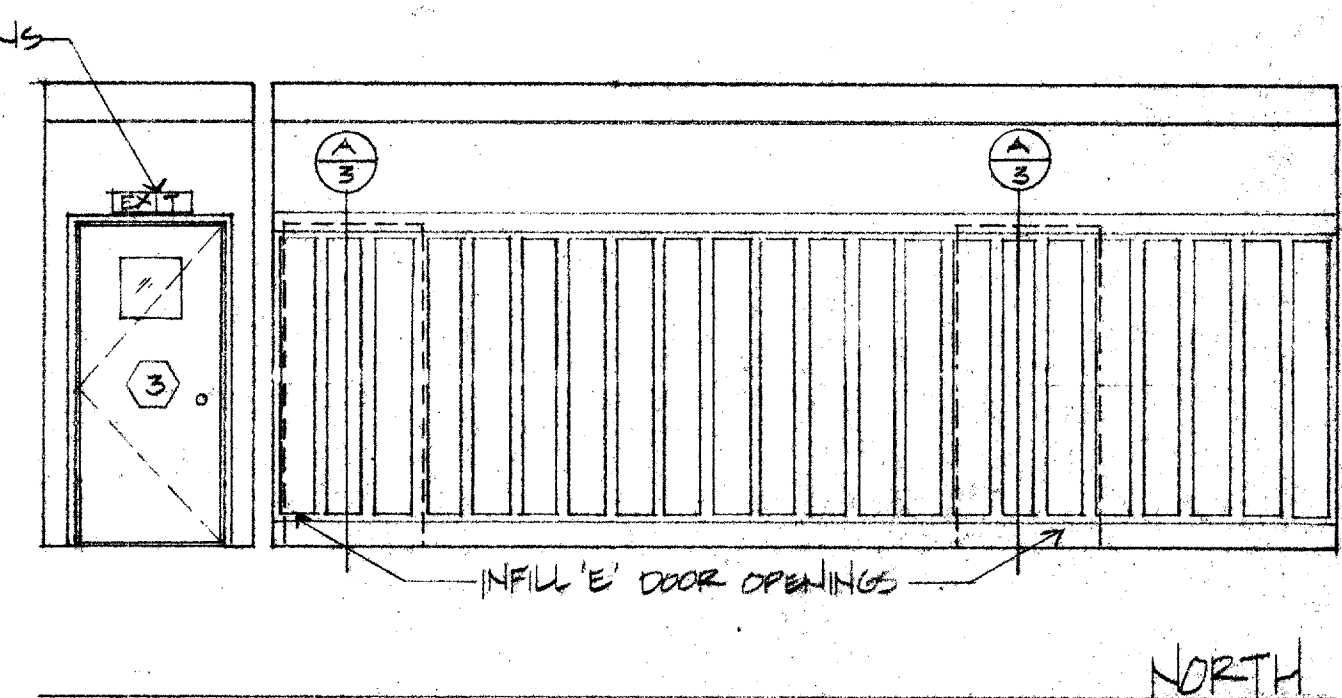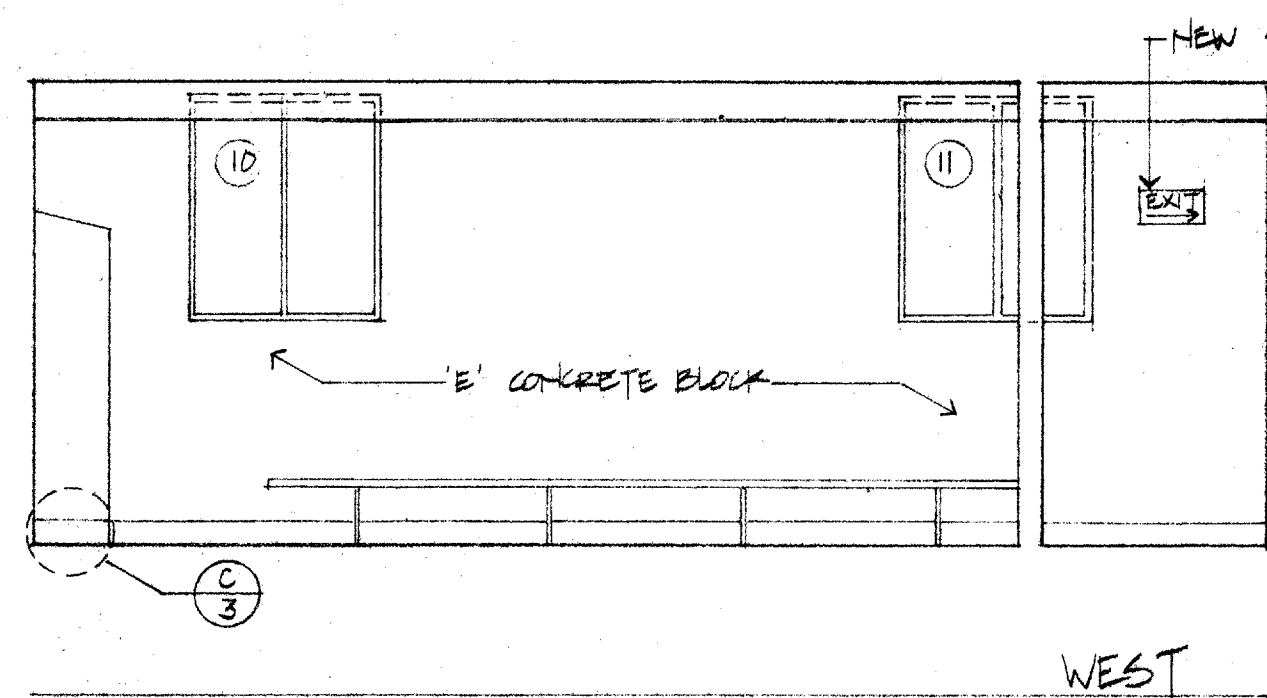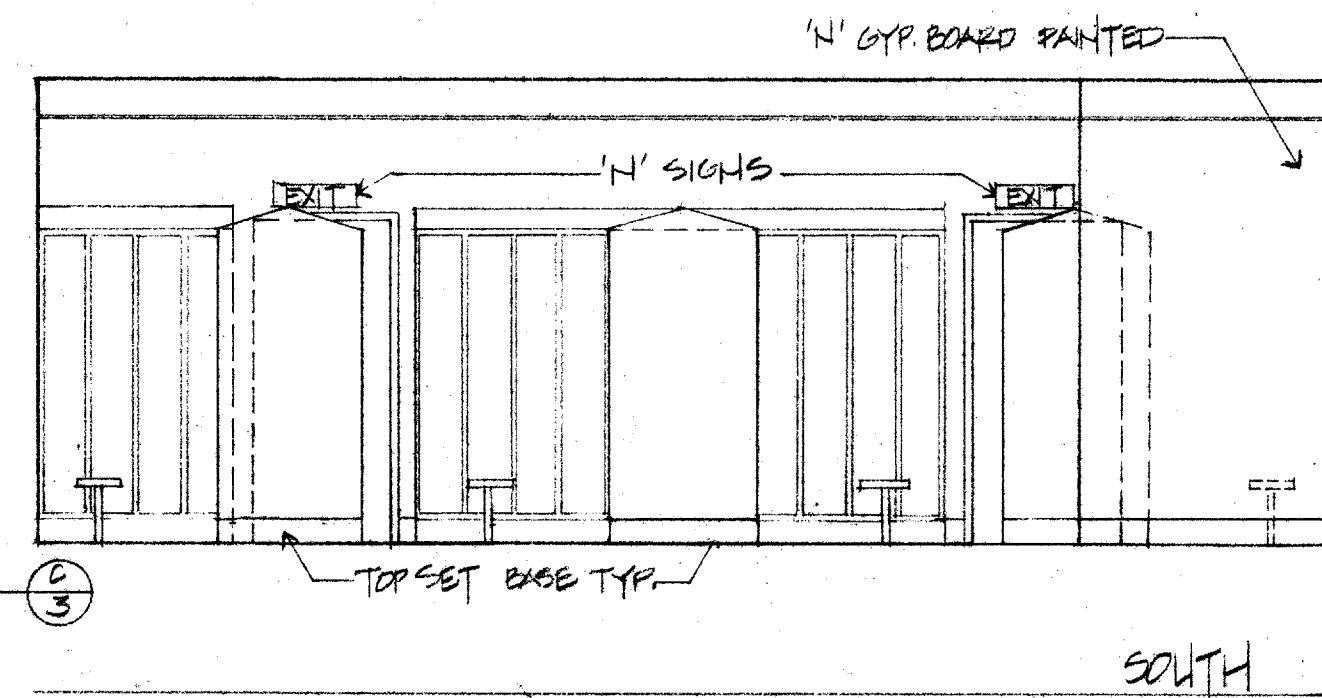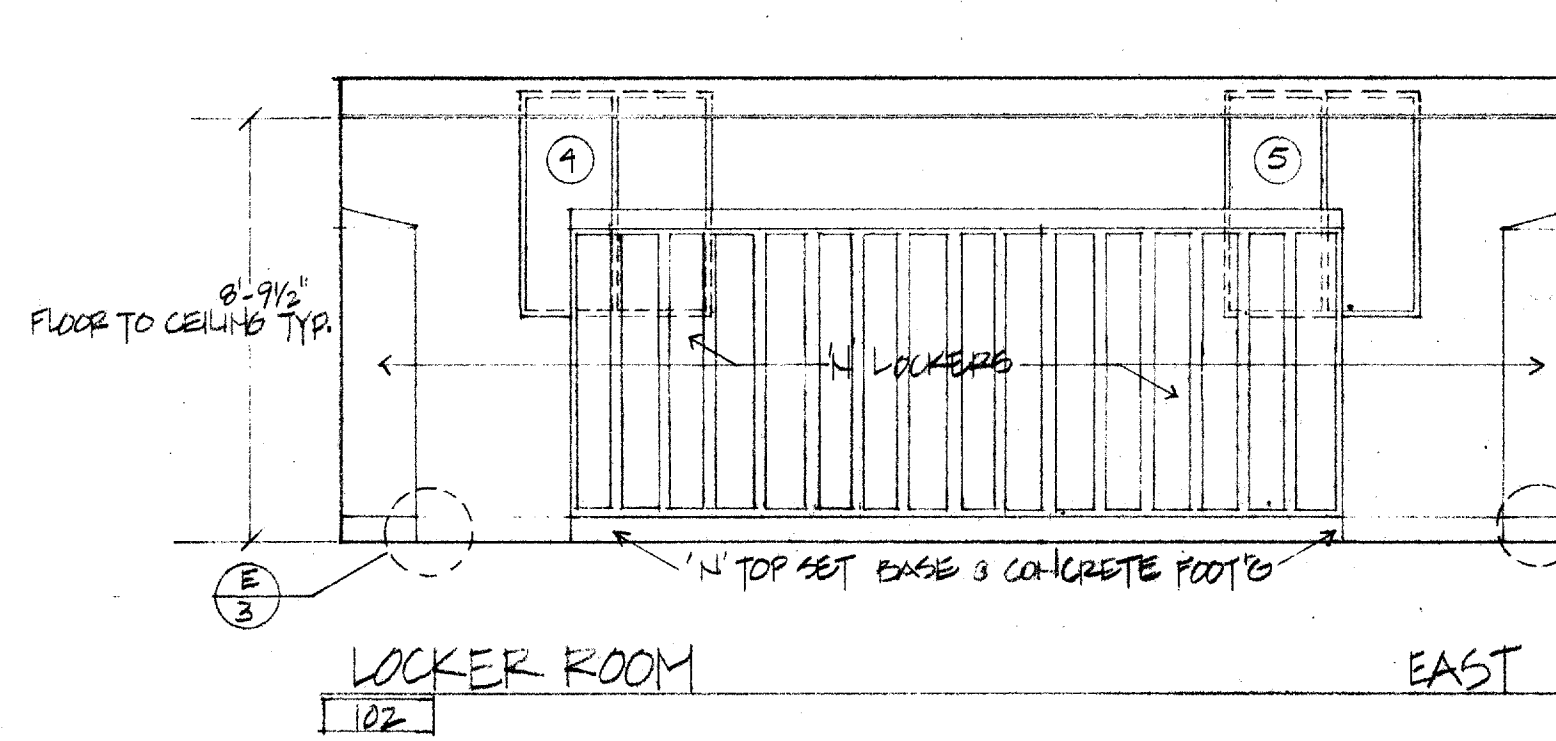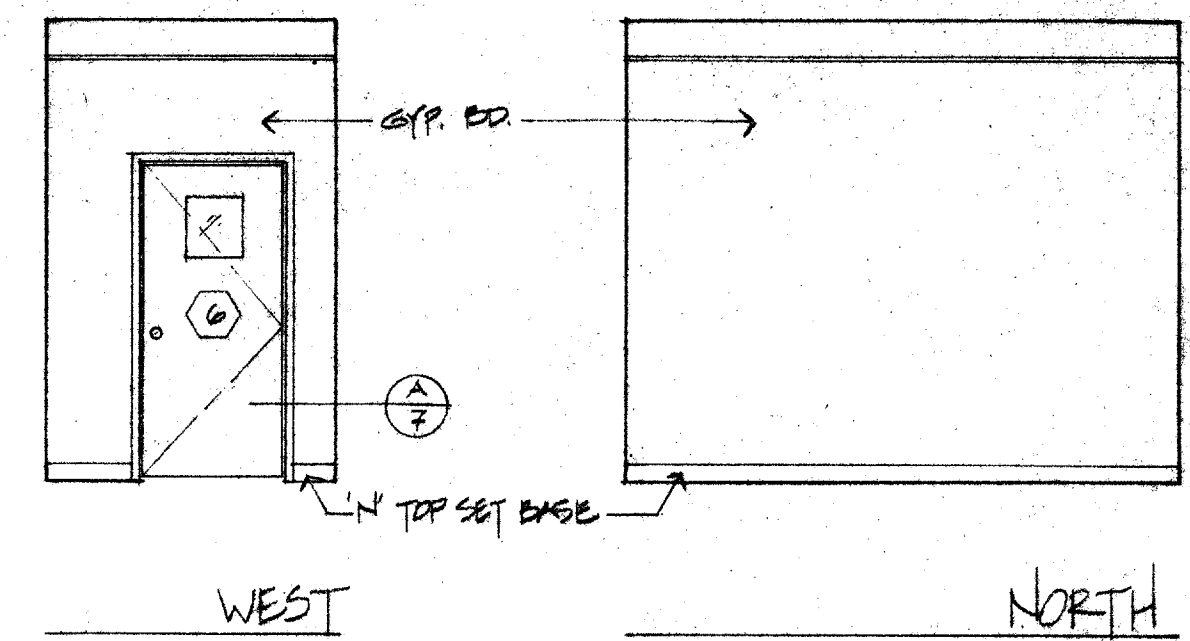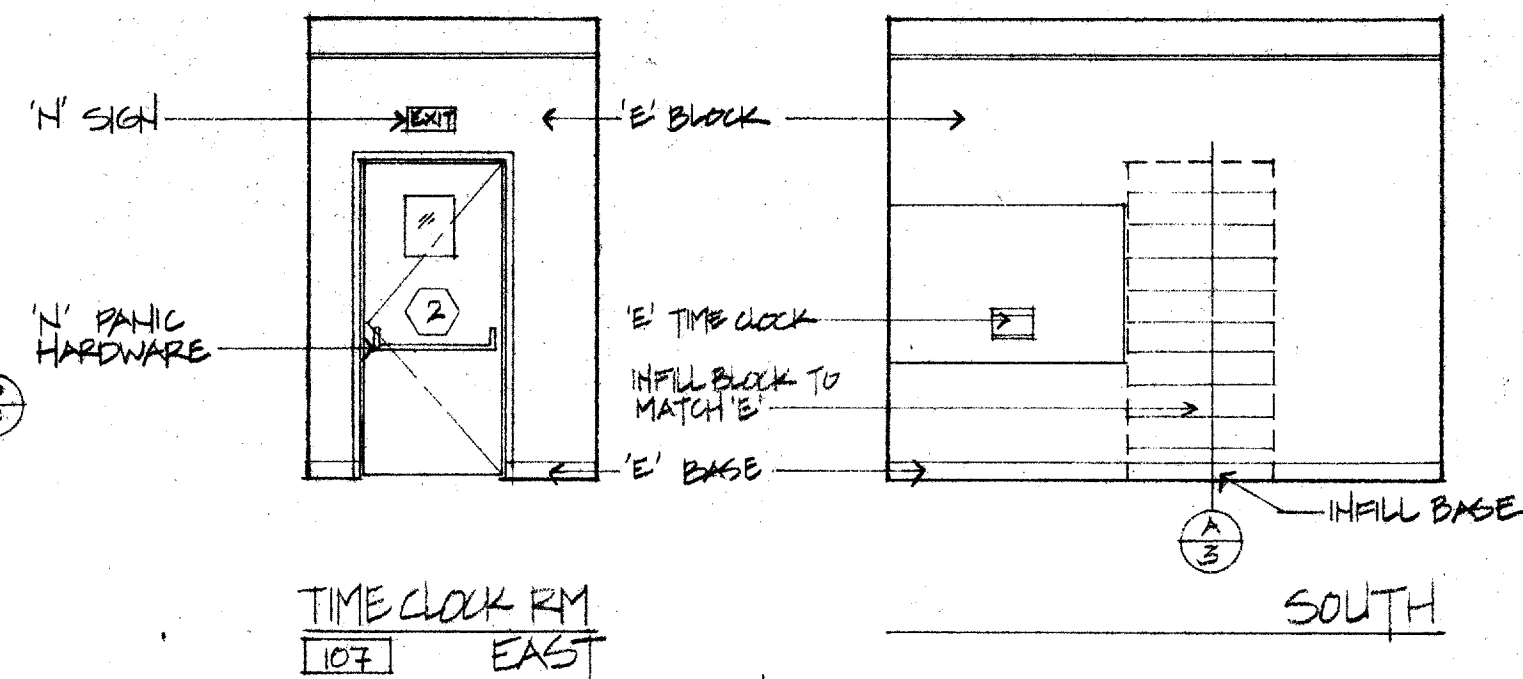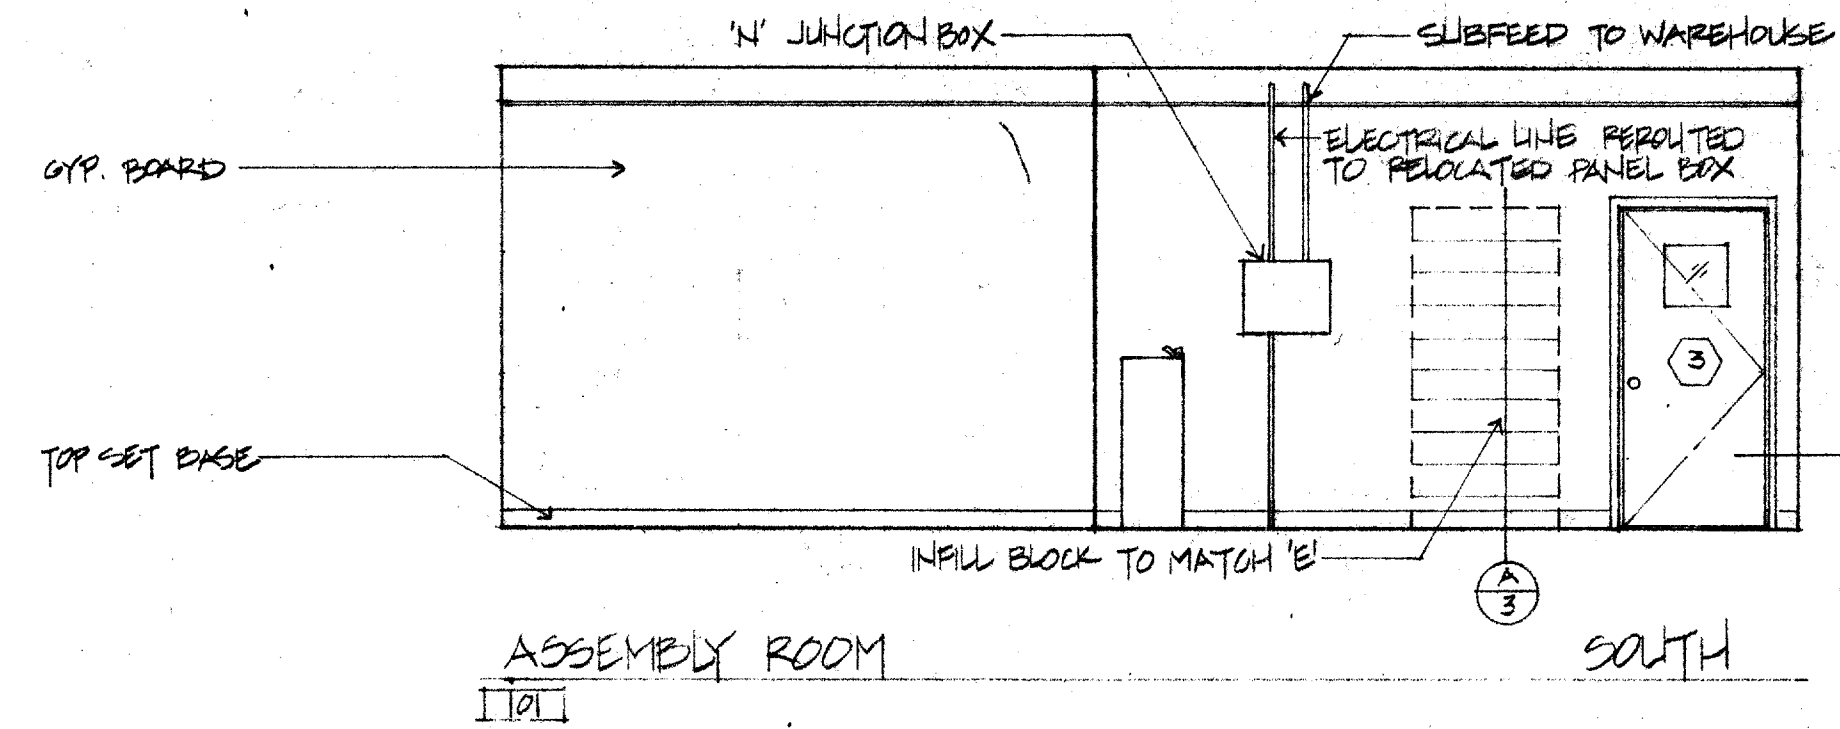

REVISIONS	BY

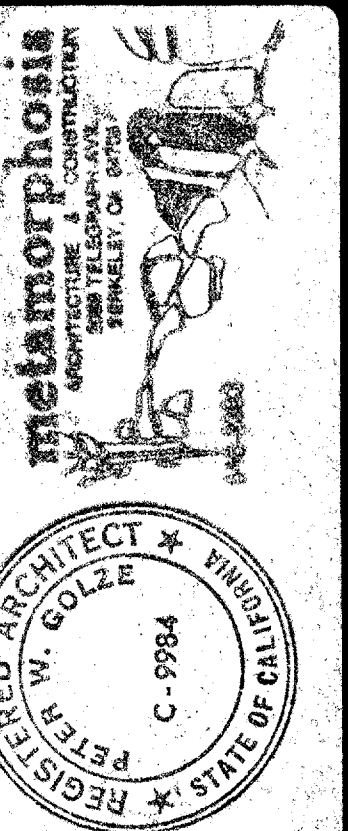

INTERIOR ELEVATIONS

ASSEMBLY BUILDING REMODEL
CITY OF BERKELEY CORPORATION YARD
1326 Allison Way, Berkeley, California


DRAWN BY	
CHECKED BY	
DATE	12-6-85
SCALE	1/4\"=1'-0"
JOB NO.	8515
SHEET	5
OF 14 SHEETS	

FINISH SCHEDULE						
ROOM NO.	ROOM NAME	FLOOR	WALLS	CEILING	BASE	REMARKS
101	ASSEMBLY ROOM	'E' VINYL TILE - PATCH AS REQUIRED	'E' BLOCK, PAINTED - INFILL AS SHOWN, REPAINT ALL SO WALL	'E' SUSPENDED ACQUIS- TICAL TILES IN 'E' GRID, PATCH AS REQUIRED	'E' TOP SET, PATCH AS REQUIRED	WORK RESTRICTED TO CUT & PATCH AS SHOWN, MATCH 'E'
102	LOCKER ROOM	"	PERIMETER - 'E' BLOCK - 'N' PAINT; 'N' WALLS - 3/8" GYP BOARD - PAINTED	"	'N' TOP SET BASE	
103	WASH ROOM	'N' CERAMIC TILE	"	"	"	
104	SHOWER ROOM	'N' CERAMIC TILE	CORIAN WALL PANELS OVER WATERPROOF GYP BOARD	CORIAN WALL PANELS OVER WATERPROOF GYP BOARD	CERAMIC TILE CURB	
105	JANITORS' ROOM	'N' CERAMIC TILE	PERIMETER - 'E' BLOCK - 'N' PAINT - 'N' WALLS - 3/8" GYP BOARD PAINTED	'E' SUSPENDED ACQUIS- TICAL TILES IN 'E' GRID	'N' TOP SET BASE	
106	VESTIBULE	'N' CERAMIC TILE	'E' BLOCK - 'N' PAINT - WATER- PROOF GYP BOARD PAINTED & CERAMIC TILE	'N' SUSPENDED ACQUIS- TICAL TILE LAYOUT - MATCH MATL TO 'E'	"	
107	TIME CLOCK ROOM	'E' VINYL TILE	'E' BLOCK - 'N' PAINT, 'N' WALLS - 5/8" GYP BOARD PAINTED	"	"	
108	WATER HEATER ROOM	'N' CONCRETE SLAB	'N' CONCRETE BLOCK - EXTERIOR PAINTED, INTERIOR UNPAINTED	GYP BR PAINTED	---	
NOTES:						

WINDOW SCHEDULE				
NO.	SIZE	TYPE	HARDWARE	REMARKS
1	'E' (42x48)	STEEL FRAME, CASEMENT		
2				APPLY 'N' GLAZING COMPOUND TO 'E' LITE
3			REPLACE CRANK	
4			"	
5			"	
6				REPLACE PLY. PANEL WITH 'N' PLEXI- GLASS - TRANSLUCENT (EXHAUST FAN)
7				
8				
9				SAME AS 6
10				
11			REPLACE CRANK	
12				
13				APPLY 'N' GLAZING COMPOUND AT 'E' LITE
14	↓	↓		
NOTES:				

DOOR SCHEDULE						
NO.	THICK- NESS	SIZE	TYPE	HARDWARE GROUP	REMARKS	FRAMES
1	1 3/4	32 x 6 1/2	HOLLOW METAL, GALV. STEEL	5	FORERER MANUFACTURER - TYPE FV PANIC HARDWARE & EXIT SIGN WEATHERSTRIPPING #306A	METAL AT 'E' BLOCK
2	(1'E')	---	---	1	'E' WITH 'N' PANIC HARDWARE & EXIT SIGN	---
3	1 3/8	32 x 6 1/2	SC WOOD - PAINT GRADE	2	VIEW PANEL, EXIT SIGN	METAL AT CUT IN 'E' BLOCK
4	1 3/8	32 x 6 1/2	"	2	VIEW PANEL, EXIT SIGN	WOOD - PRE-HUNG
5	1 3/8	32 x 6 1/2	"	2	VIEW PANEL, EXIT SIGN	WOOD - PRE-HUNG
6	1 3/8	32 x 6 1/2	SC WOOD - PAINT GRADE	3	VIEW PANEL PANIC HARDWARE & EXIT SIGN	WOOD - PRE-HUNG
7	1 3/8	32 x 6 1/2	GC WOOD - PAINT GRADE	3	PANIC HARDWARE & EXIT SIGN	"
8	1 3/8	32 x 6 1/2	SC WOOD - PAINT GRADE	4	TOP & BOTTOM FIXED LOUVERED VENTS	"
9	---	---	OMITTED	---	---	---
10	1 3/4	32 x 6 1/2	HOLLOW METAL, GALV. STEEL	5	FORERER MANUFACTURER - TYPE F PANIC HARDWARE & EXIT SIGN WEATHERSTRIPPING #306A	METAL AT 'E' BLOCK
11	1 3/4	32 x 6 1/2 PR.	"	6	FORERER MANUFACTURER - TYPE FL (AIR LOUVERS) WEATHERSTRIPPING #306A	METAL AT 'N' BLOCK
NOTES:						


REVISIONS	BY

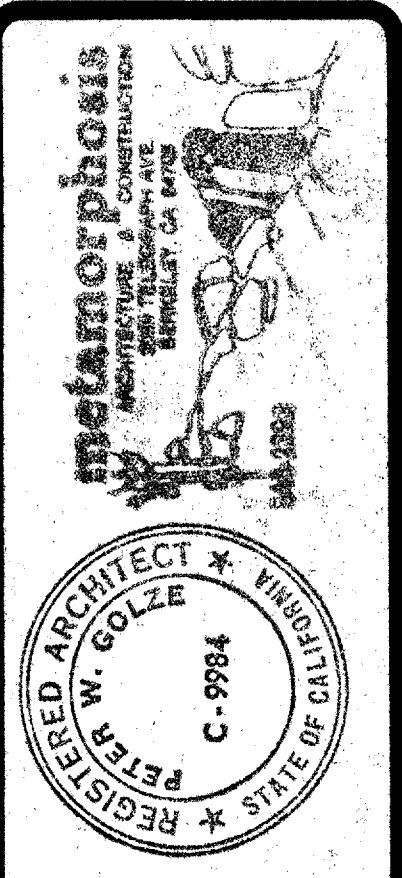

FIXTURE
SCHEDULES-
PARKS DEPT.
BUILDING


ASSEMBLY BUILDING REMODEL
CITY OF BERKELEY CORPORATION YARD
1326 Alston Way, Berkeley, California

DRAWN B/C
CHECKED R/C
DATE 12-6-85
SCALE
JOB NO. 8515
SHEET 6
OF 14 SHEETS

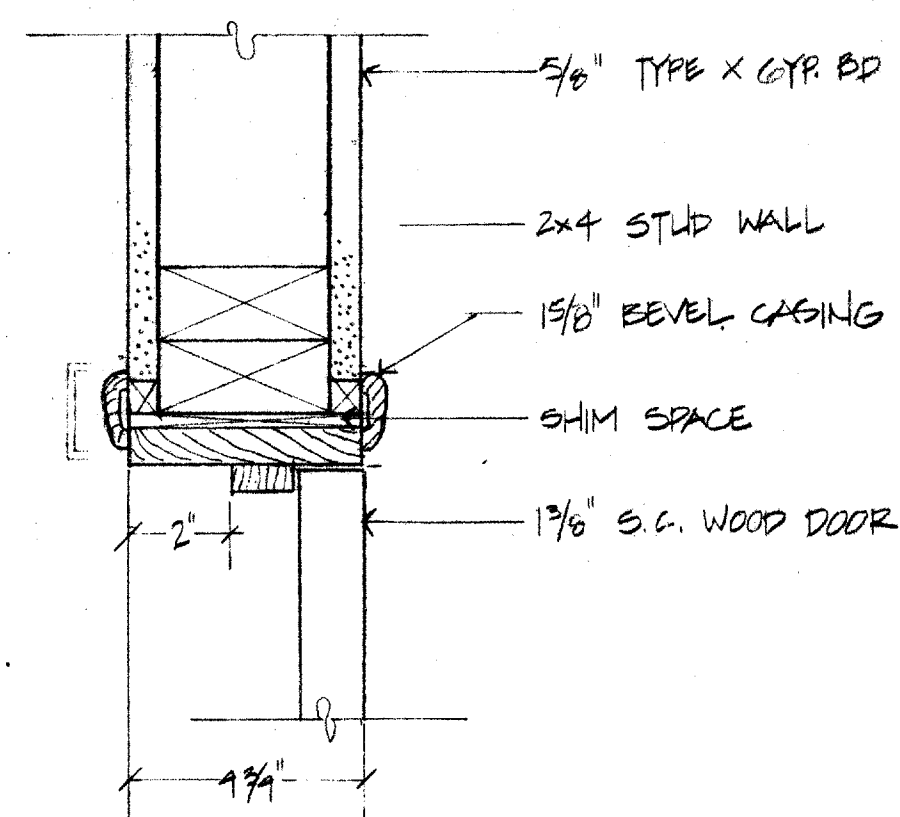


A JAMB (HEAD SIM.)
3"=1'-0"

N' DOOR AT STUD WALL
SEE PLAN FOR ORIENTATION

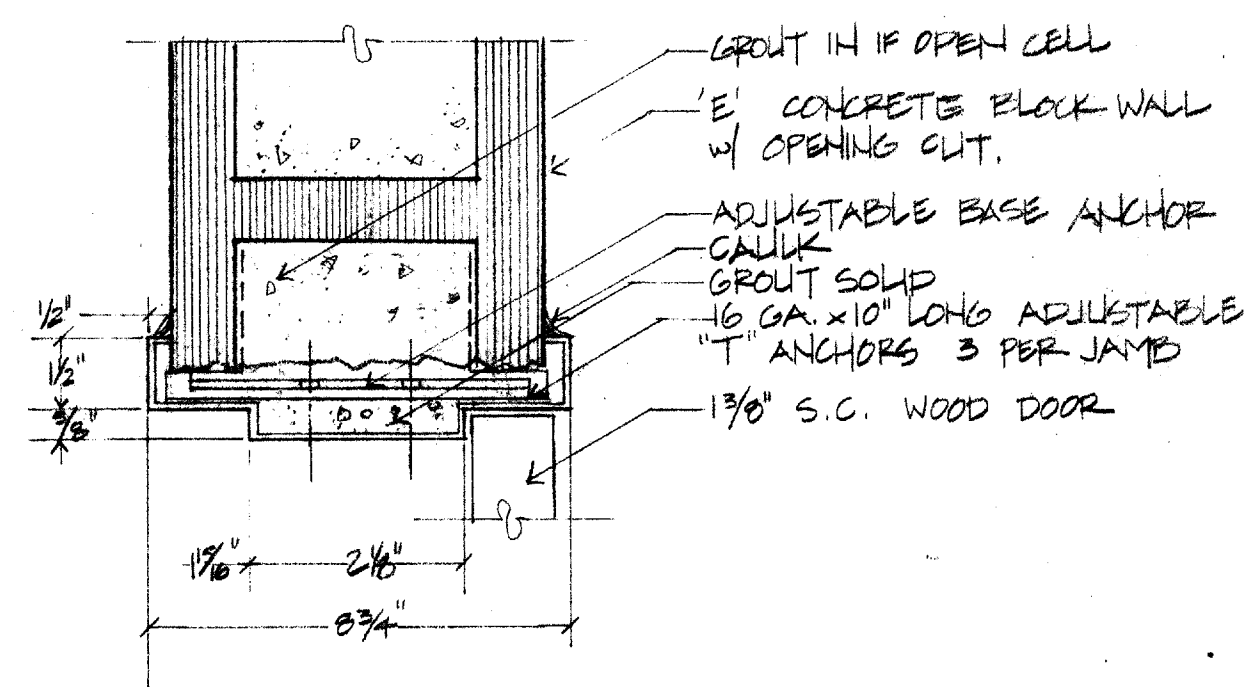


B JAMB (HEAD SIM.)
3"=1'-0"

N' DOOR AT 'E' BLOCK
SEE PLAN FOR ORIENTATION

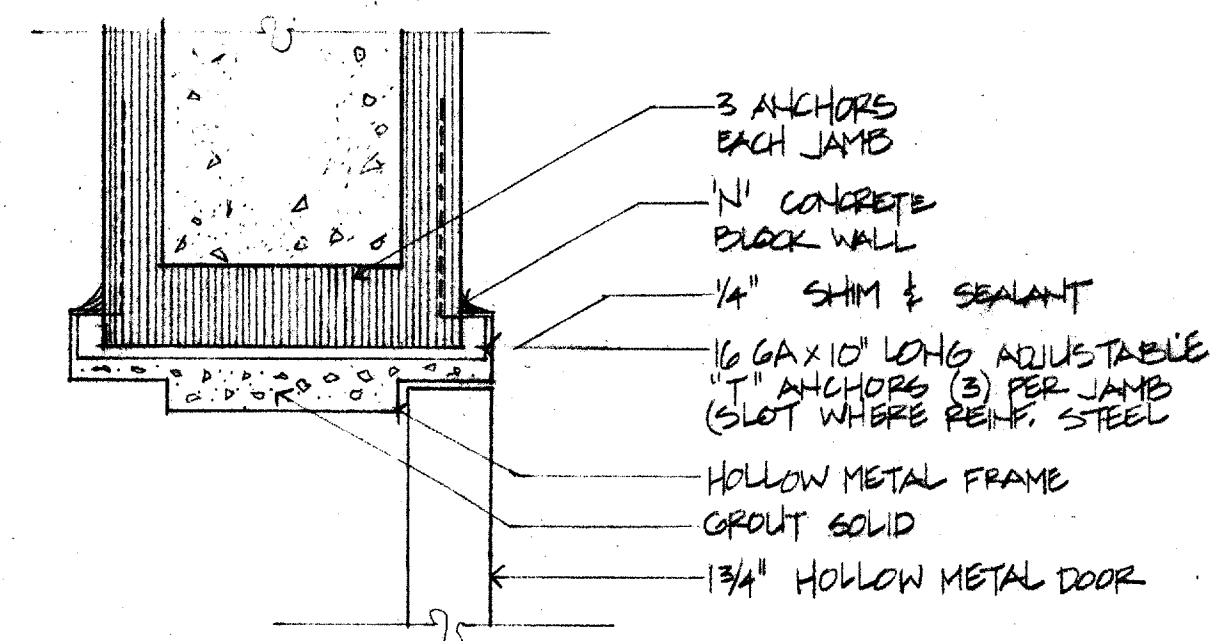


C JAMB (HEAD SIM.)
3"=1'-0"

N' DOOR AT 'N' BLOCK
SEE PLAN FOR ORIENTATION

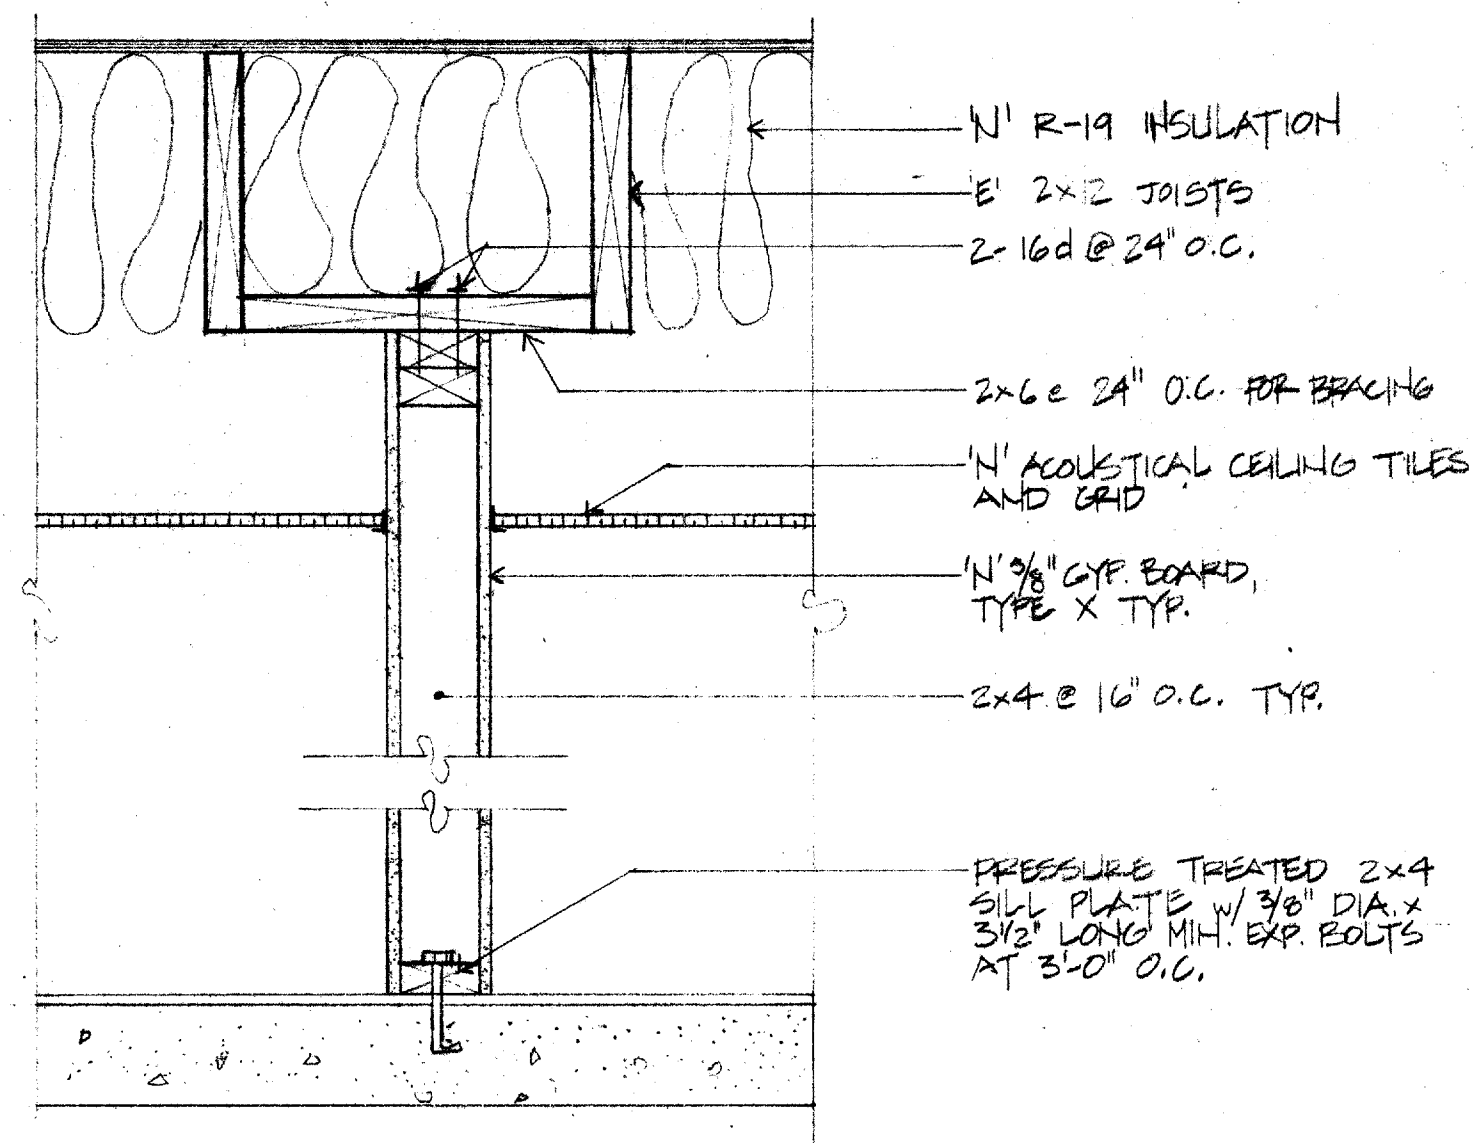


D STUD WALL
1 1/2"=1'-0"

PARALLEL TO ROOF JOISTS

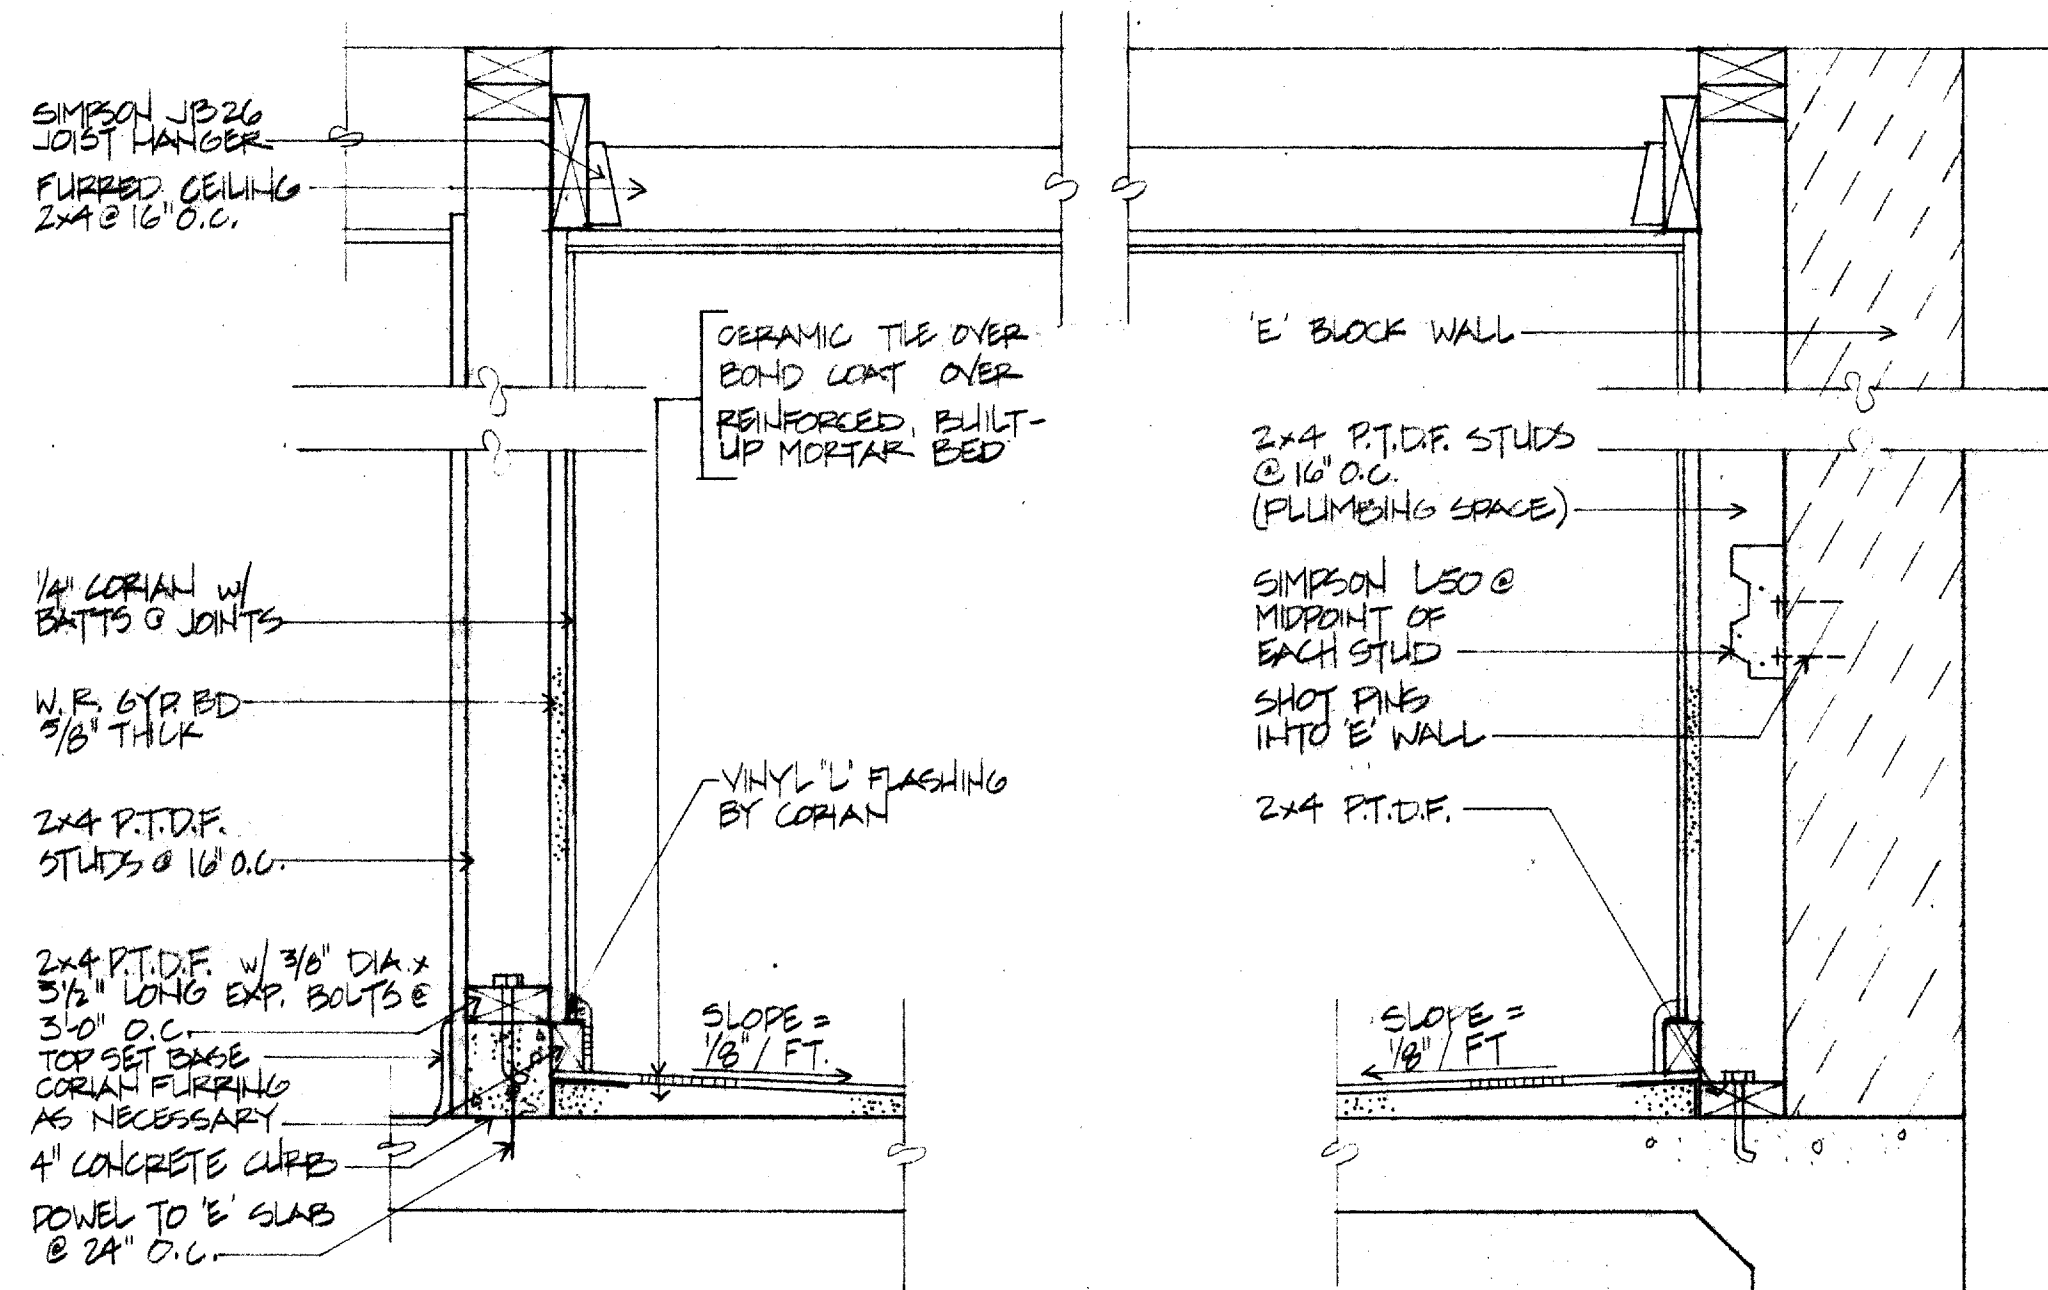


E SHOWER STALL WALL AND CEILING
1 1/2"=1'-0"

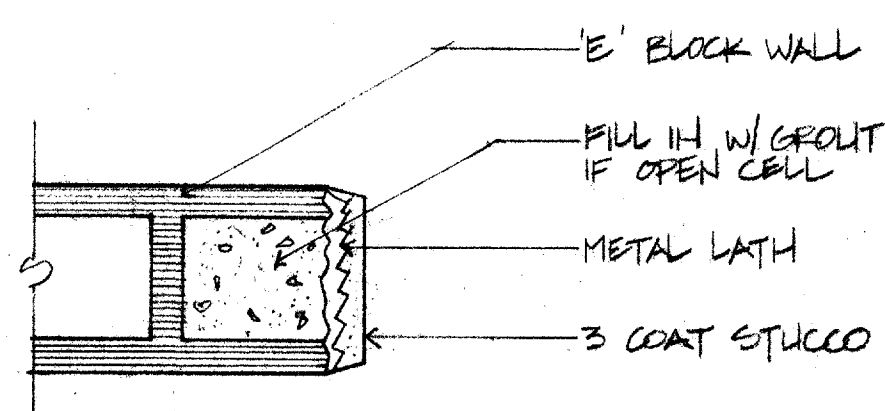


F OPENING IN BLOCK WALL
1 1/2"=1'-0"


BETWEEN 'E' SHOWERS

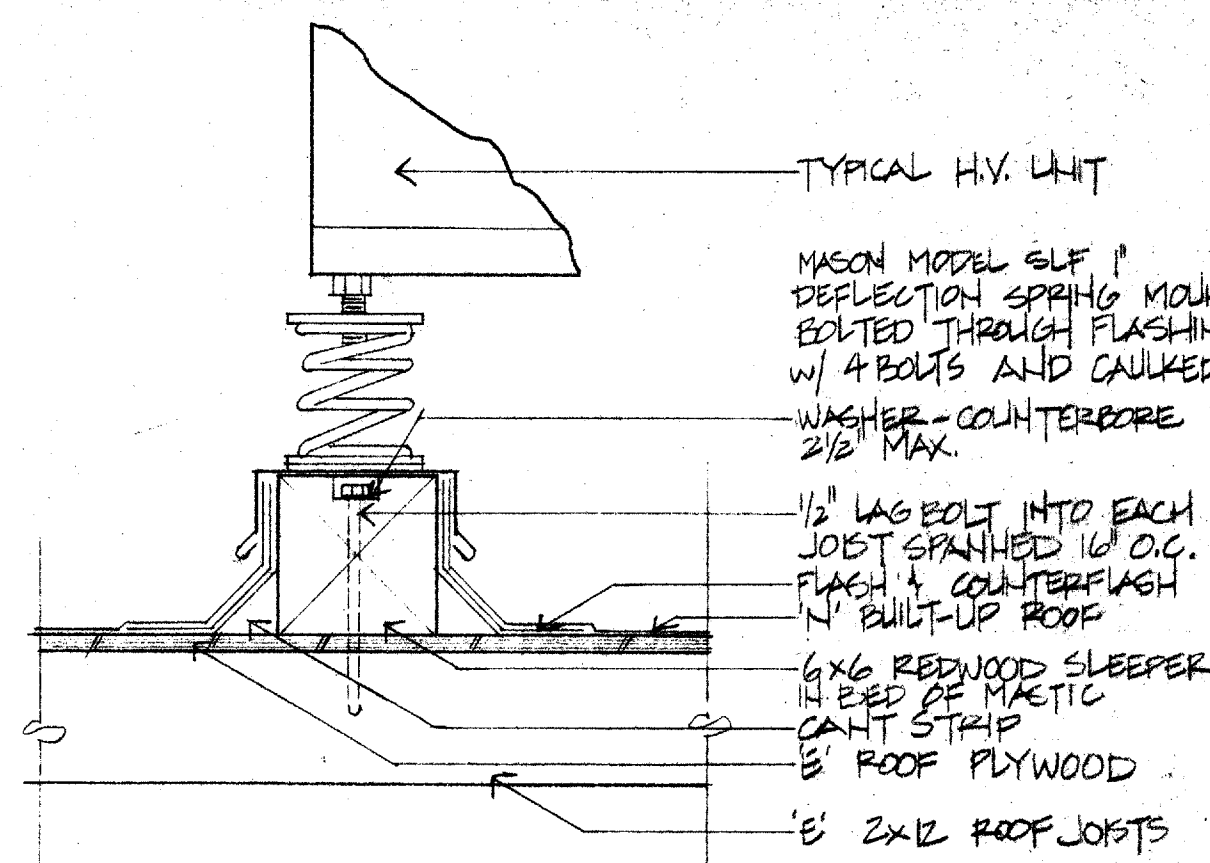

G H.V. UNIT-SUPPORT SYSTEM
NO SCALE

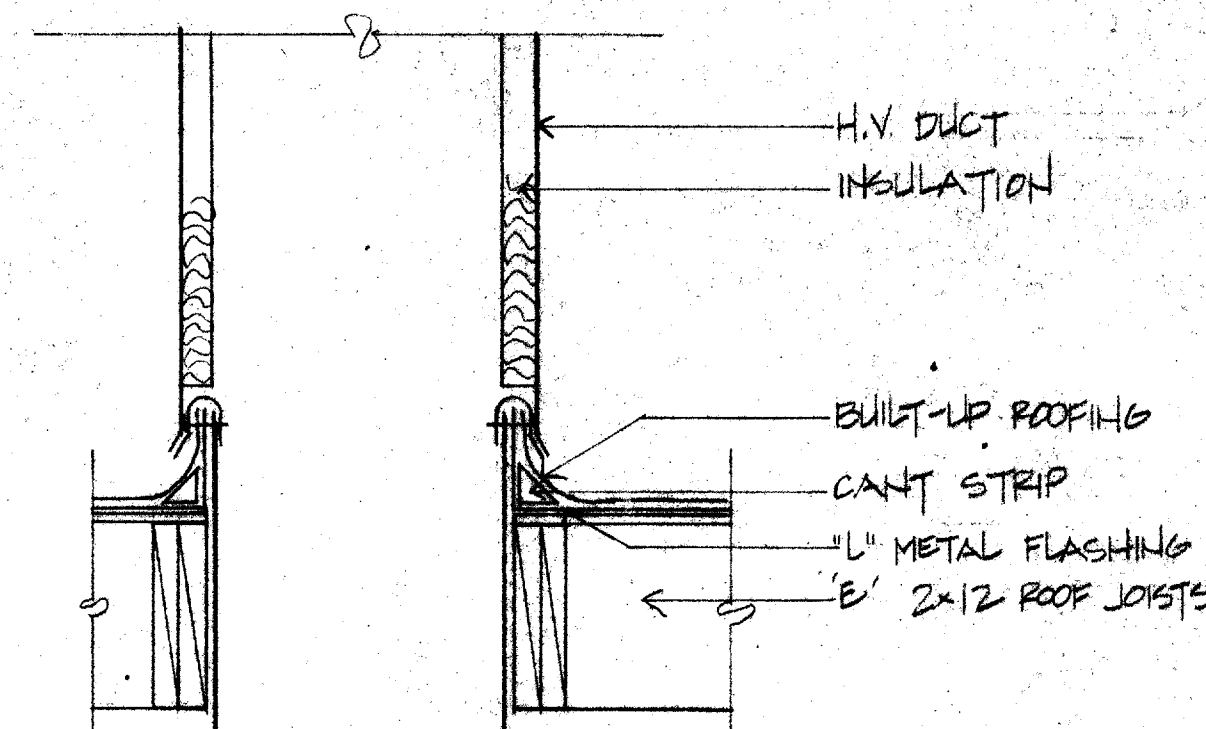


K DUCT PENETRATION
1"=1'-0"

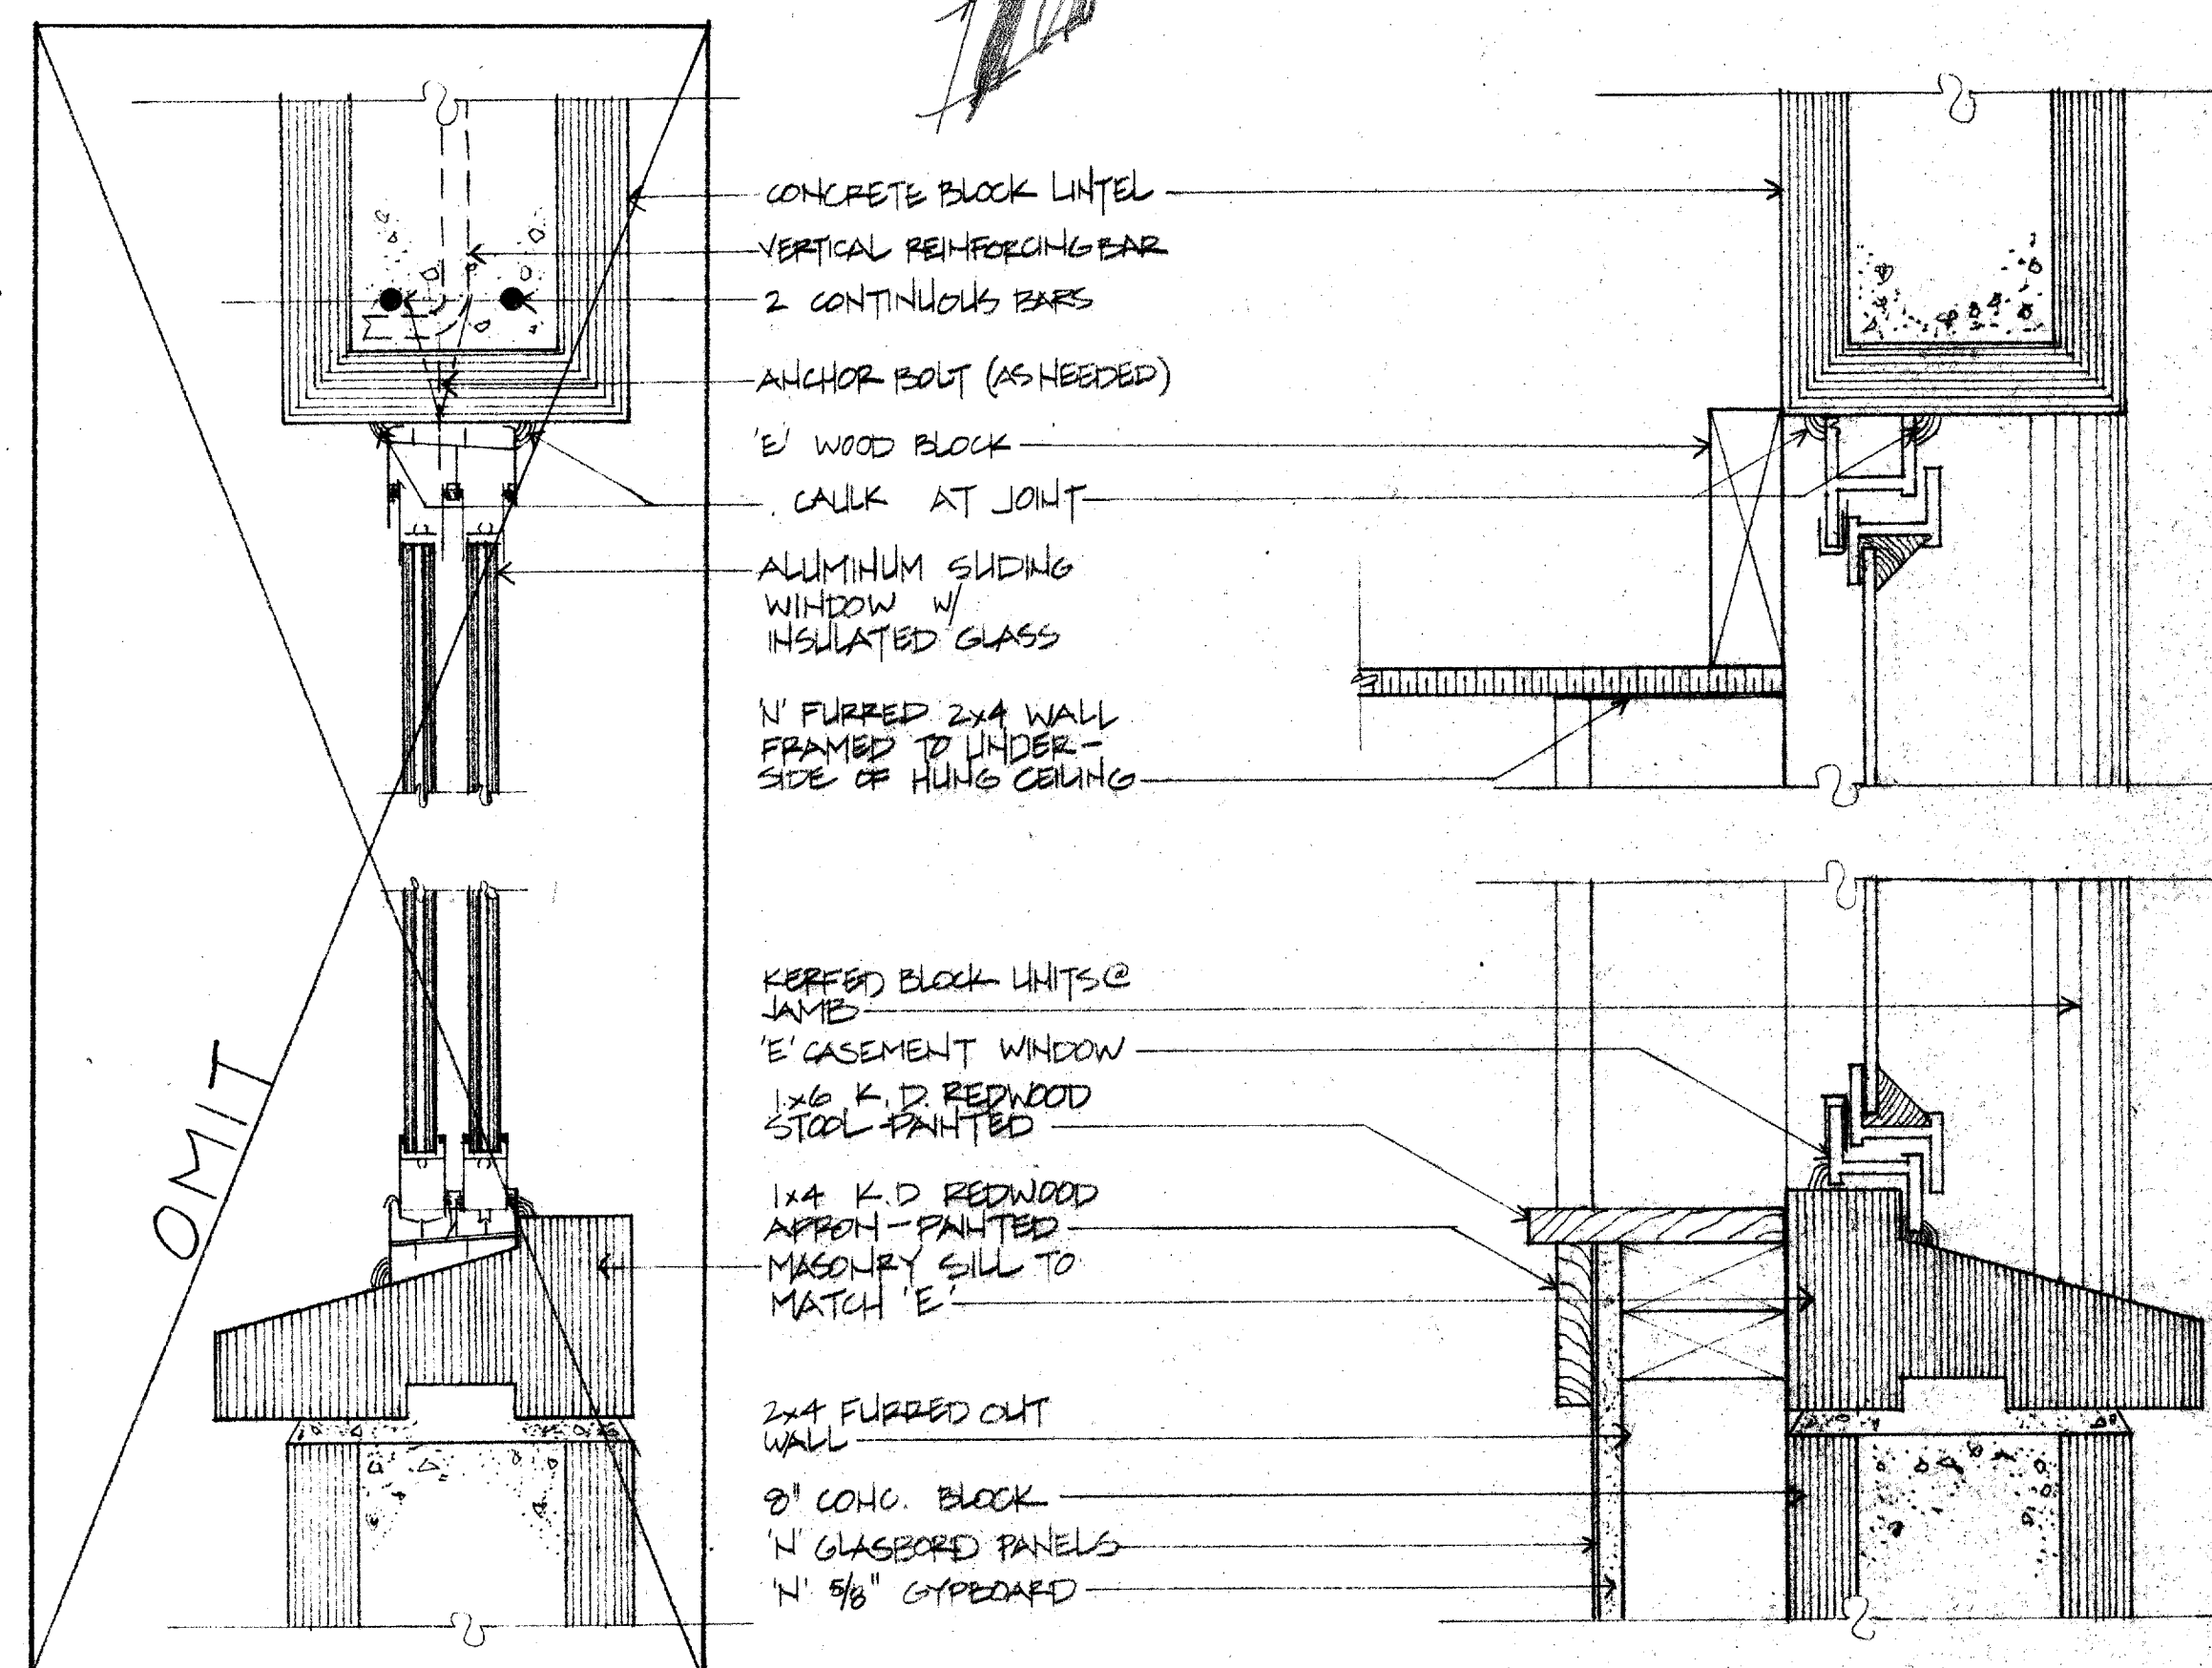

H GUARD ROOM SLIDER
NO SCALE


L FURRED WALL AT 'E' WINDOW
3"=1'-0"

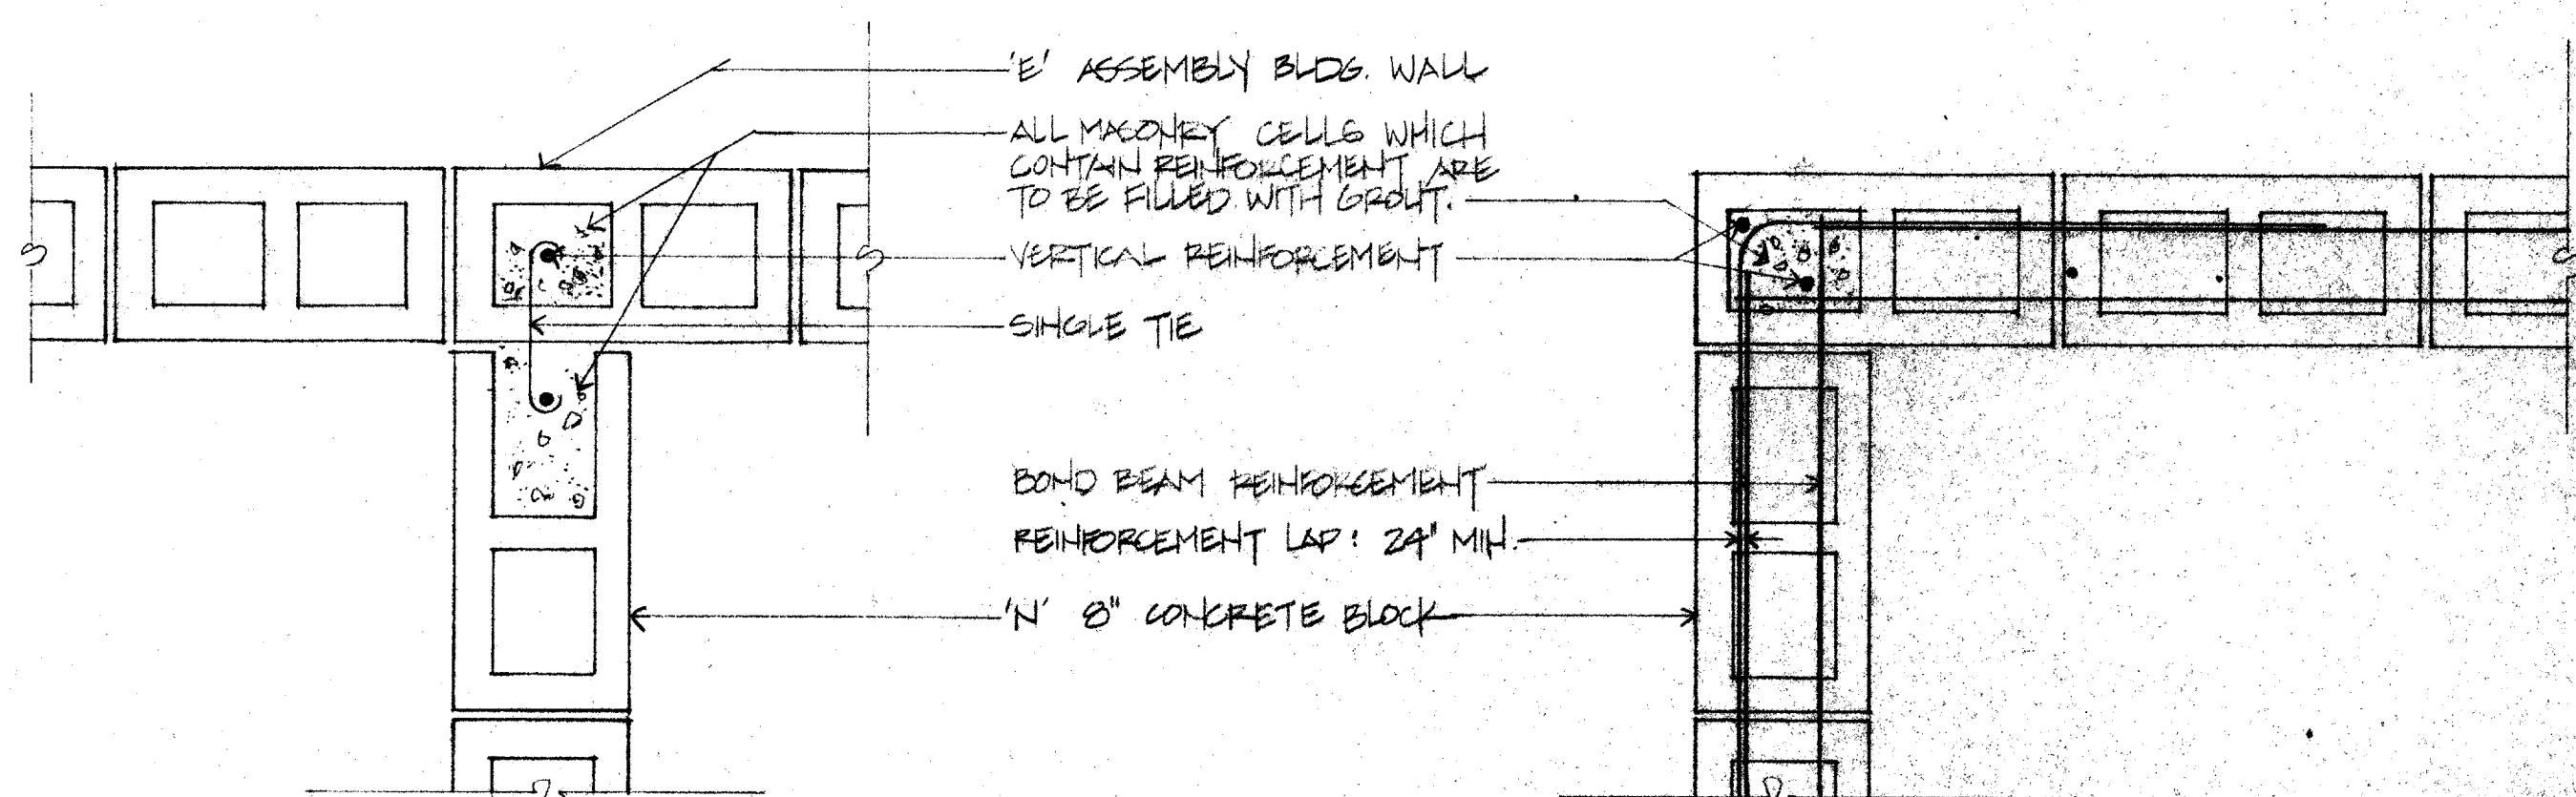

J INTERSECTION: 'N' AND 'E' MASONRY WALLS
1 1/2"=1'-0"

M CORNER AT 'N' MASONRY WALL
1 1/2"=1'-0"


REVISIONS	BY

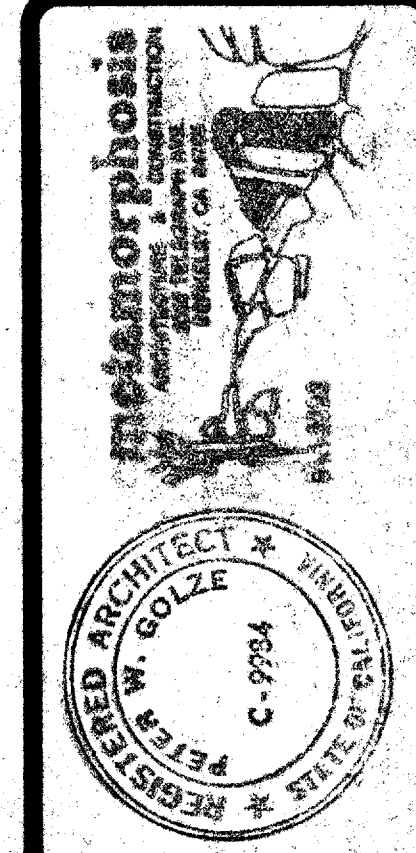

DETAILS

ASSEMBLY BUILDING REMODEL
CITY OF BERKELEY CORPORATION YARD
1326 Allston Way, Berkeley, California

DRAWN	D.V.
CHECKED	P.C.
DATE	12-6-88
SCALE	AS NOTED
JOB NO.	8815
SHEET	7
OF 14 SHEETS	

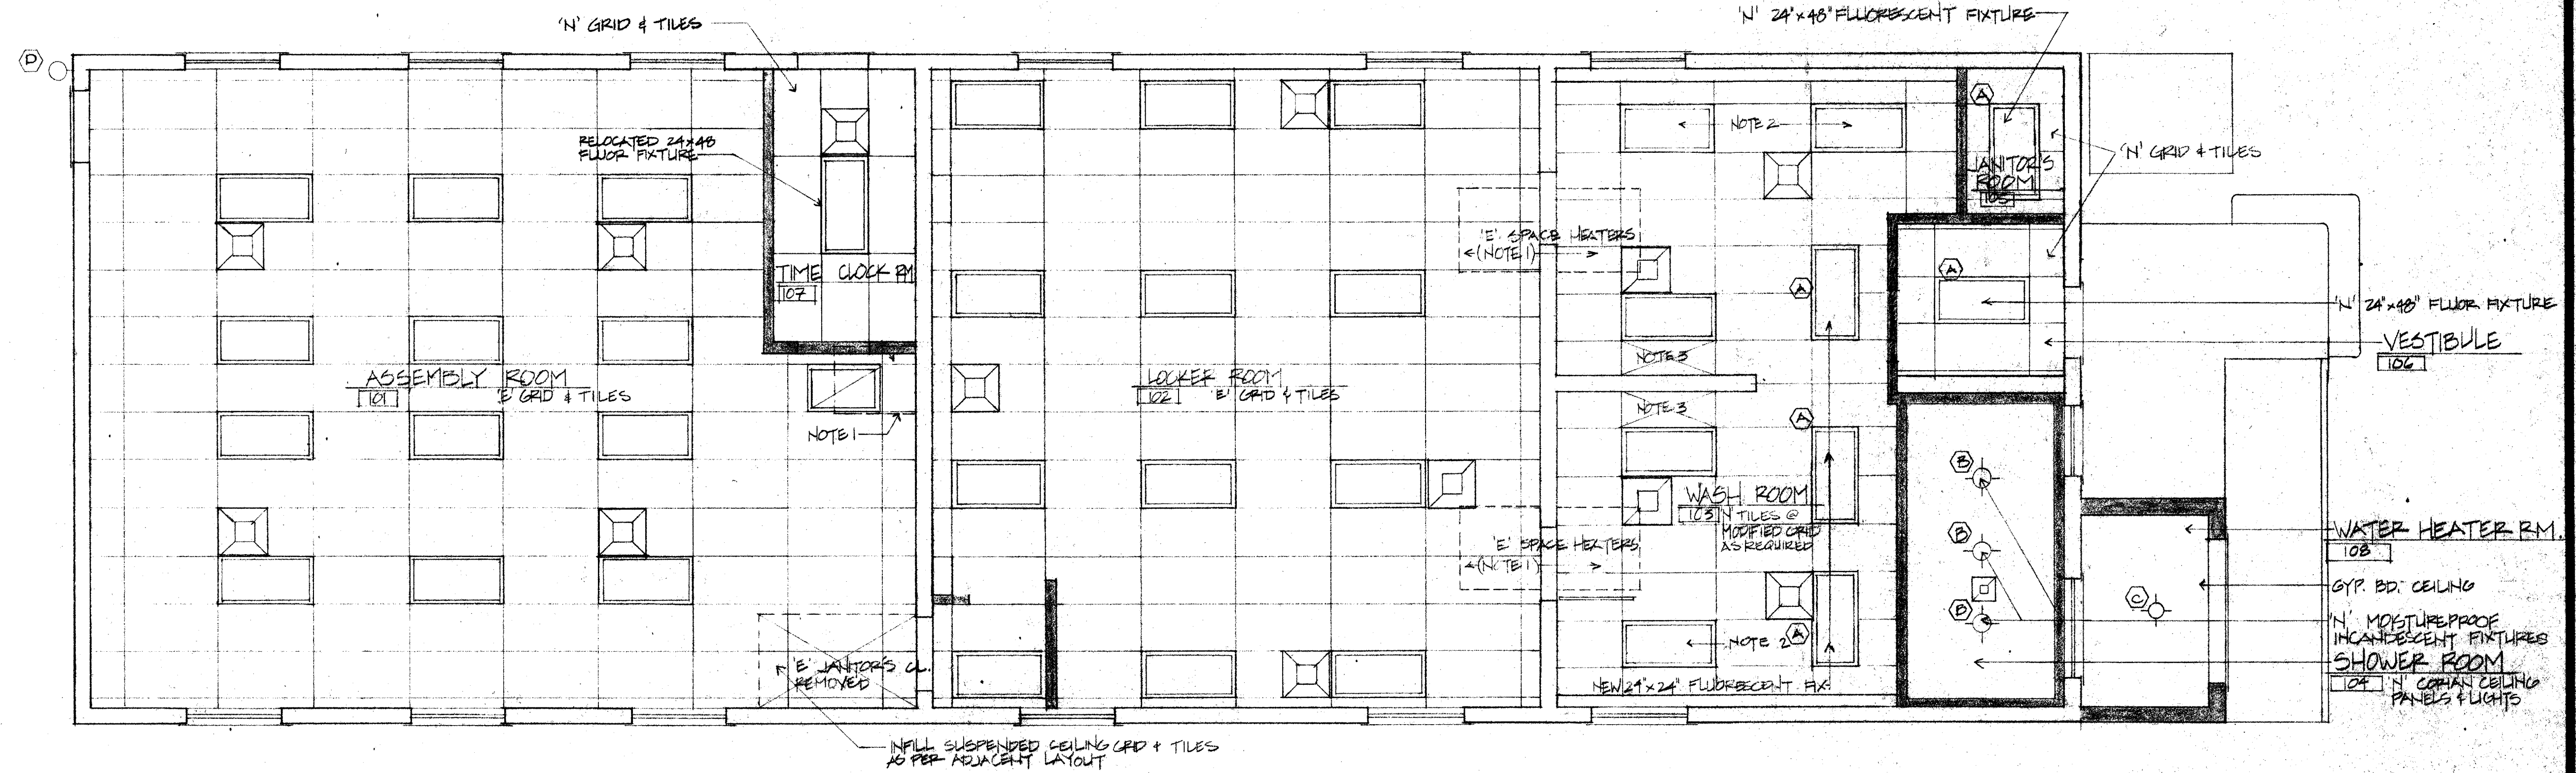

REFLECTED CEILING PLAN


1/4"=1'-0"

NOTES:

1. REMOVE 'E' GAS CEILING SPACE HEATER, CAP EXISTING GAS SUPPLY LINE ABOVE CEILING AND FILL SUSPENDED CEILING TO MATCH ADJACENT LAYOUT.
2. REMOVE AND RELOCATE 'E' FLUORESCENT FIXTURE, REPLACE OPERING WITH ACOUSTICAL SUSPENDED CEILING TILE.

3. REMOVE AIR RISER GRILLE AND REPLACE WITH ACOUSTICAL CEILING TILE.

4. ○ REFER TO LIGHTING SCHEDULE, PAGE 12.

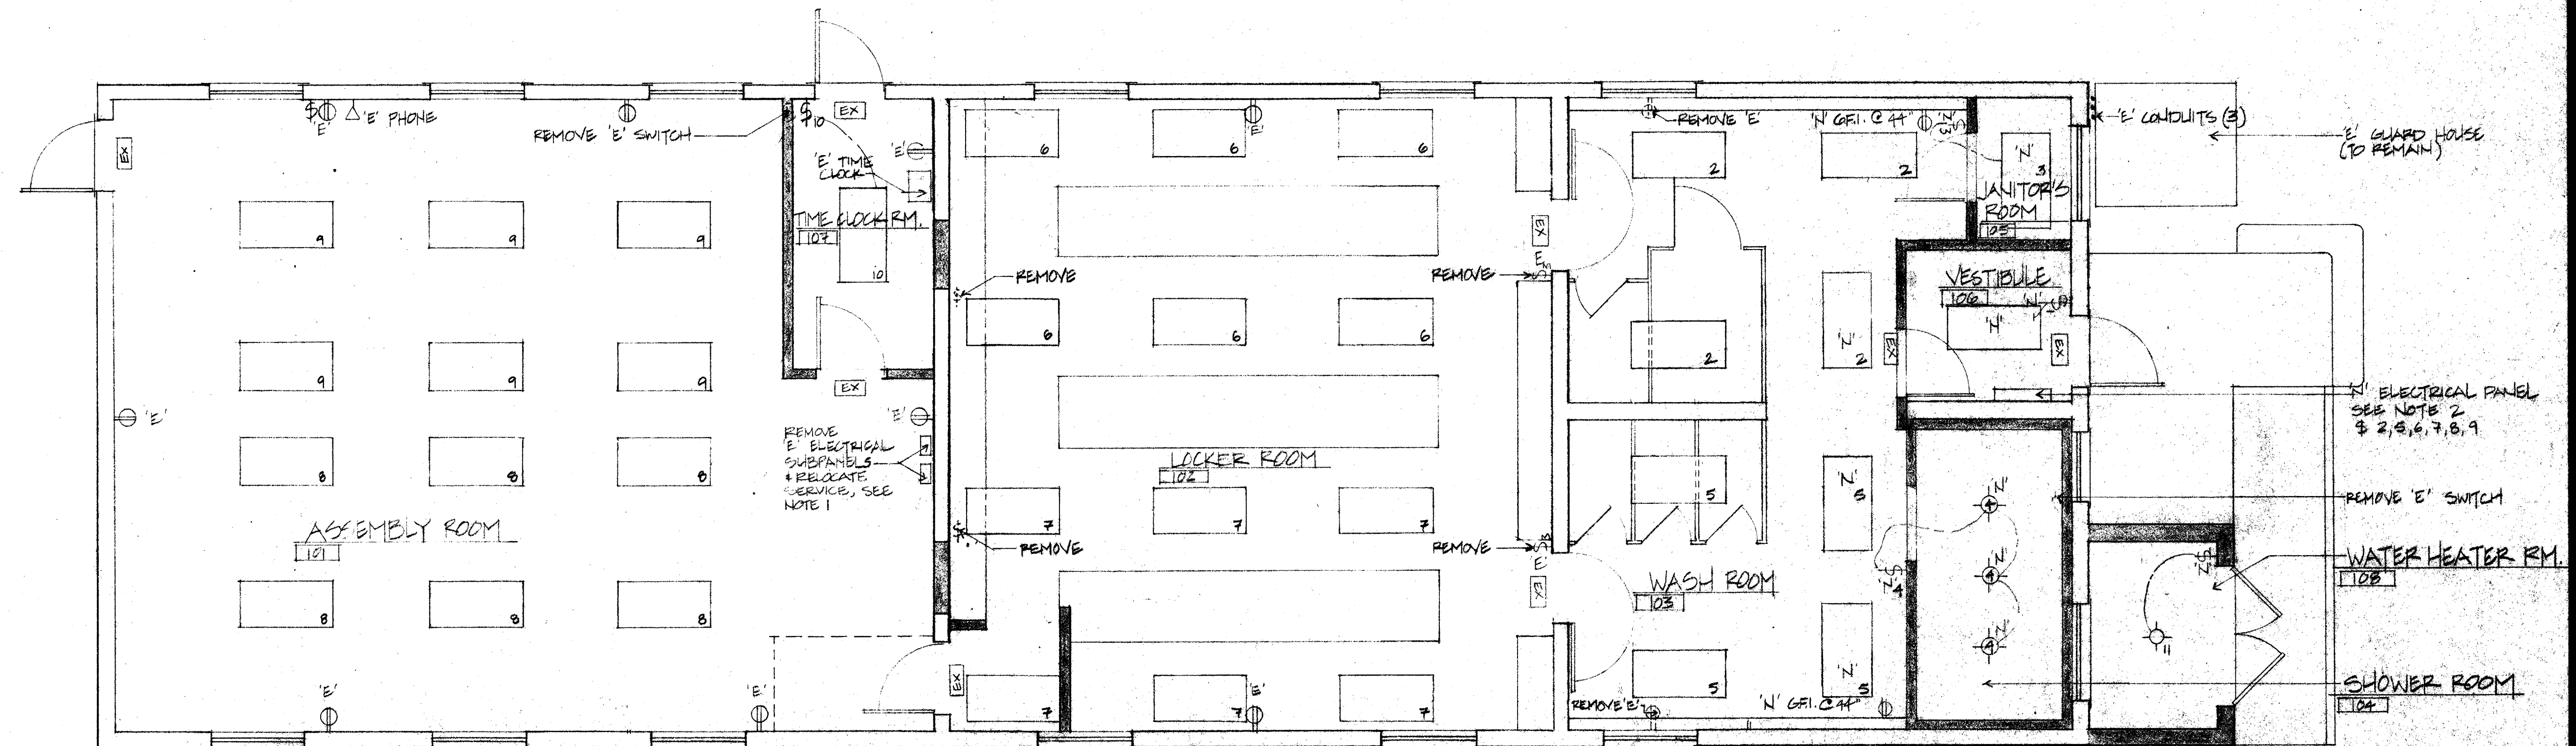

ELECTRICAL PLAN


1/4"=1'-0"

NOTES:

1. EXISTING (TO BE REMOVED): 70 AMP FEED (3"4 WIRE) FROM MAIN SUBPANEL IN METER ROOM (SEE SITE PLAN, SHEET 1) IN BURIED PIPE TO WALL MOUNTED FUSE BOX, WITH 60 AMP DISCONNECT FOR 50 AMP FEED TO ADJACENT WAREHOUSE BUILDING.
2. NEW: PULL NEW 150 AMP FEED IN 'E' BURIED PIPE FROM METER ROOM (N 200 AMP FUSE) TO CIRCUIT BOX AT VESTIBULE (ROOM 106) VIA OLD LOCATION AND ACROSS ABOVE SUSPENDED CEILING.

3. EX: NEW ILLUMINATED EXIT SIGNS ABOVE DOORS AS SHOWN.


REVISIONS	BY

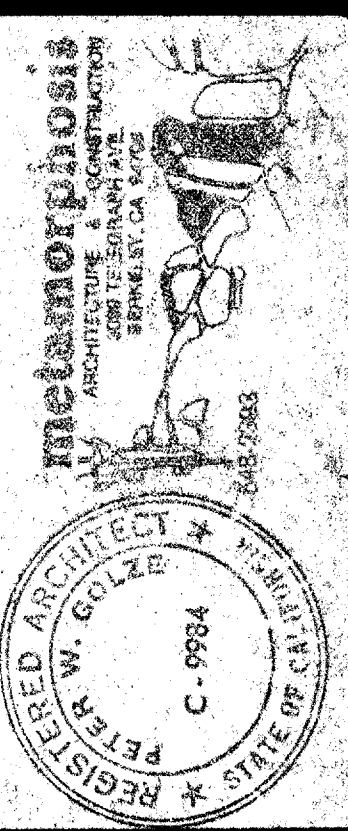

REFLECTED
CEILING PLAN
AND
ELECTRICAL
PLAN

ASSEMBLY BUILDING REMODEL
CITY OF BERKELEY CORPORATION YARD
1926 Allston Way, Berkeley, California


DRAWN	DV
CHECKED	PG
DATE	12-6-85
SCALE	1/4"=1'-0"
JOB NO.	8515
SHEET	8
OF	14 SHEETS

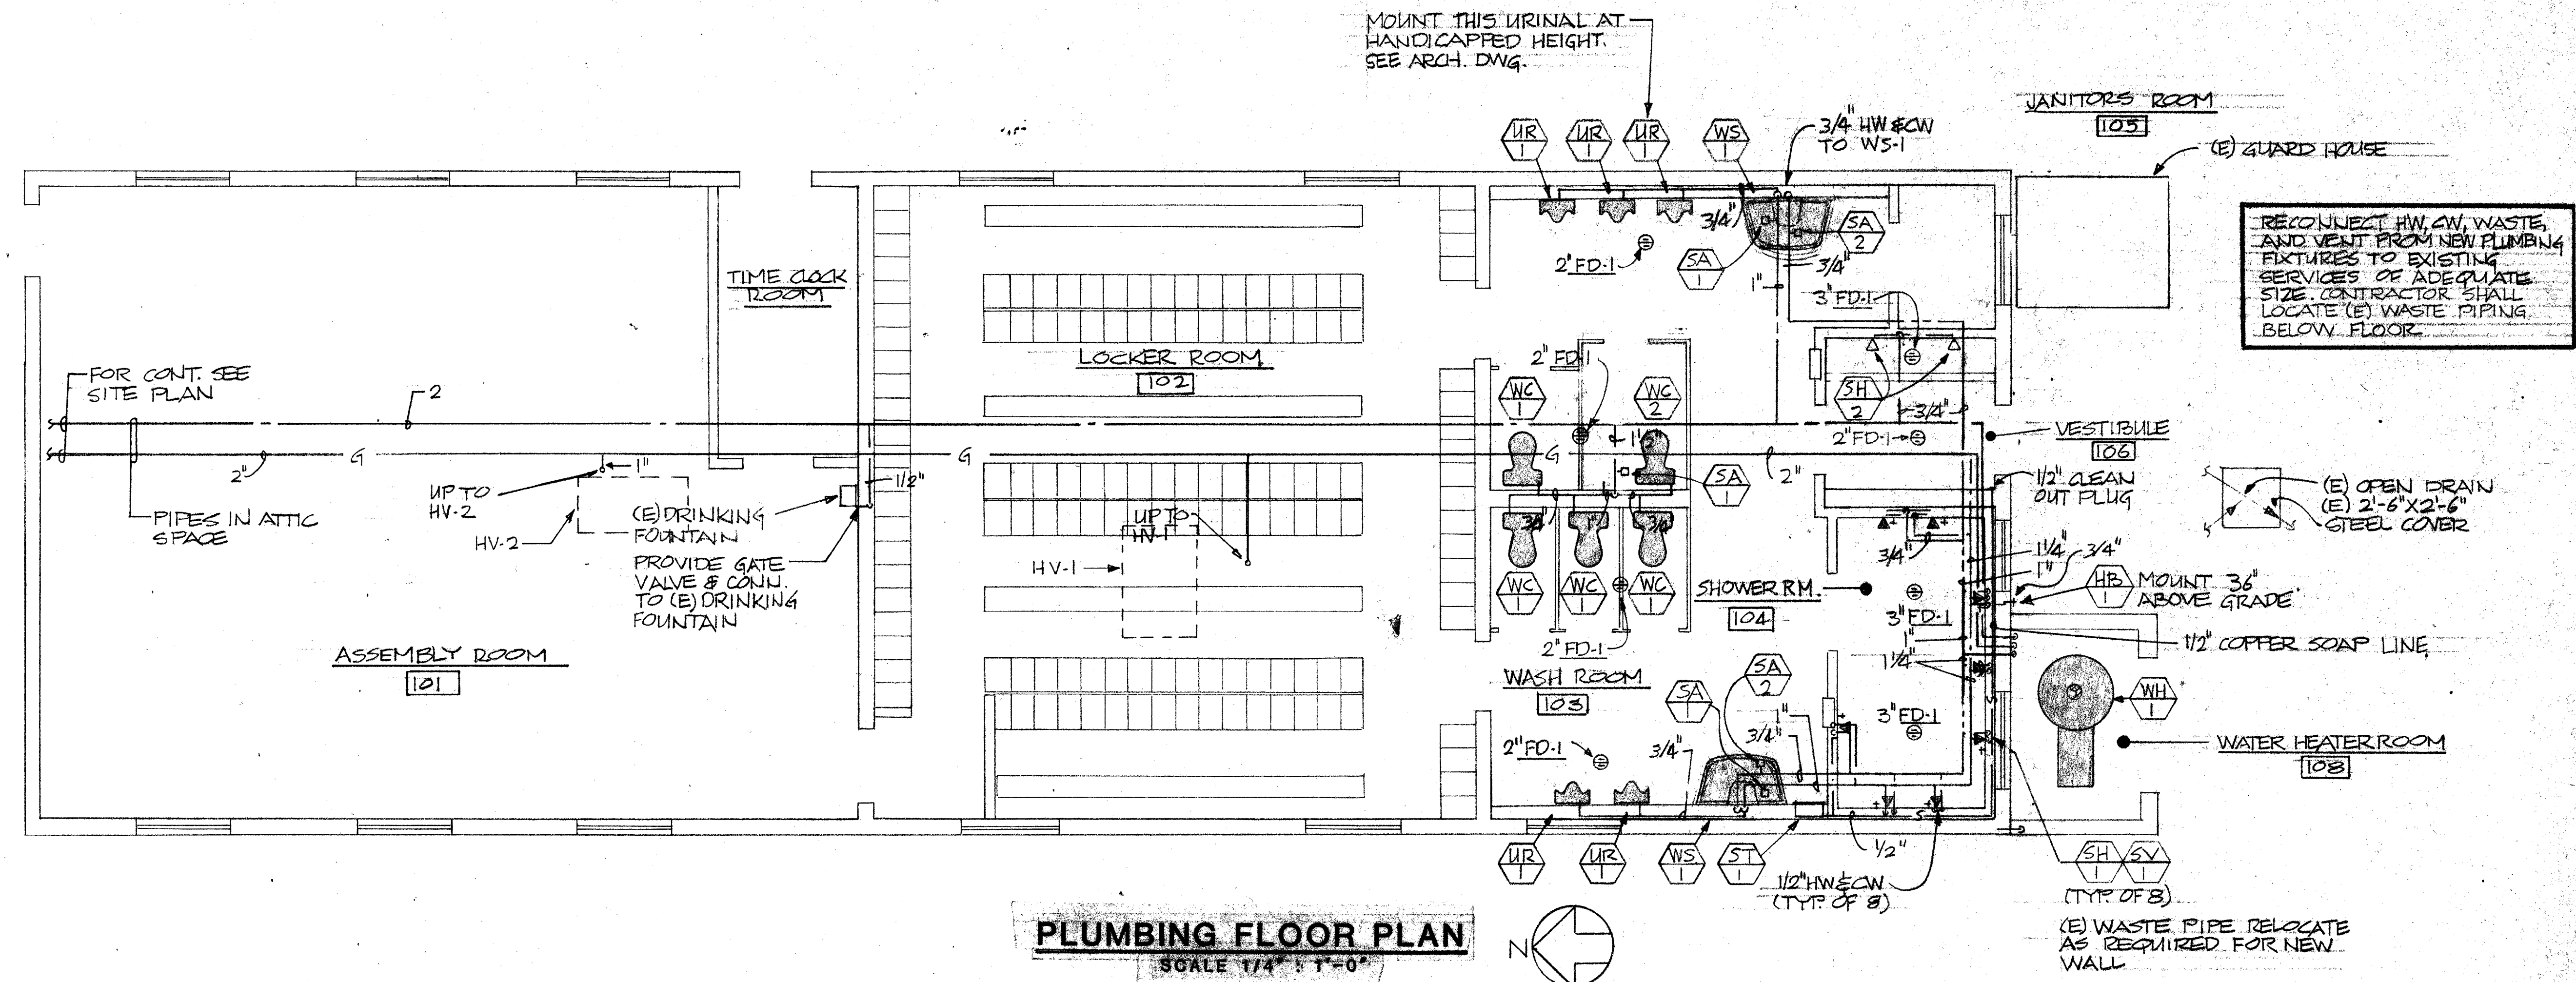

FIXTURE SCHEDULE			
SYMB.	MANUFACTURER & MODEL NO.	TRIM	REMARKS
WC	AMERICAN STANDARD ELONGATED WATER-SAVER "CADET" TOILET, MODEL NO. 2109.405, VITREOUS CHINA. COLOR - WHITE	FURNISH COMPLETE WITH CLOSE-COUPLED TANK W/ WATER-SAVING TRIM, & BOLT CAPS, ANGLE SHUT-OFF VALVE, SUPPLY PIPE, OLSONITE WHITE, SOLID PLASTIC, OPEN FRONT SEAT #95	
UR	AMERICAN STANDARD WATER-SAVER "TRIMBROOK" URINAL MODEL # 6560.015 VITREOUS CHINA. COLOR - WHITE	SLOAN ROYAL NO. 186 TOP SPUD FLUSH VALVE	J.R. SMITH CARRIER #14. 635
WS	BRADLEY "QUADRA-FOUNT" PRECAST TERRAZZO WHITE MARMORITE	FURNISH WITH BACKSLASH MOUNTED SOAP VALVE COMBINATION STOP STRAINER, CHECK VALVES, NO. 222 VERNATHERM THERMOSTATIC MIXING VALVE, 1/2" IPS SUPPLY INLETS, PEDESTAL SHALL HAVE S.S. FRONT PANEL MOUNTING PANEL AND PRECAST TERRAZZO SIDE PANELS. FLOOR & BOWL ANCHOR BRACKETS.	
WC 2	BRADLEY "TRI-FOUNT" PRECAST TERRAZZO WHITE MARMORITE		
SH 1	SYMMONS 1-100 SX3 SAFETY MIX SHOWER VALVE.	SUPER SAFETY MIX LEVER HANDLE, INTEGRAL STOP, & 3 GPM FLOW RESTRICTOR. SHOWER HEAD FREE FLO #4.295 INSTITUTIONAL HEAD	
SH 2	SYMMONS 4-151 UNIVERSAL INSTITUTIONAL HEAD WITH MOUNTING BRACKET	CHICAGO FAUCET #770 WITH #633 HANDLE (COLD WATER ONLY)	
ST 1	BRADLEY RECESSED SOAP TANK MODEL # 617US, SIZE 12 1/2" X 15" X 3 1/4". 304 STAINLESS STEEL, 2 GALLON CAPACITY	COMBINATION UNION SHUT-OFF VALVE	
SV 1	VANDAL-PROOF HOODED SOAP VALVE, MODEL #483		

FIXTURE SCHEDULE			
SYMB.	MANUFACTURER & MODEL NO.	TRIM	REMARKS
FD	J.R. SMITH FLOOR DRAIN DUCO CAST IRON BODY MODEL NO. 2010A	FLASHING COLLAR, NICKEL BRONZE ADJUSTABLE STRAINER HEAD	
WH	PVI GLASSHIELD WATER HEATER, SERIES 54 G250APG, 250 GALLON STORAGE, 540MBH INPUT, 864 B.T.H. @ 60°F RISE, STANDBY HEAT LOSS 3193 BTU/HR., 1520 LBS. SHIPPING WT. 1/3 HP MOTOR, 120V/1Φ	STD. EQUIP. UPPER & LOWER THERMOSTAT. TEMPERATURE LIMITING DEVICE. COMBINATION HIGH & LOW PRESSURE & LOW WATER PROTECTIVE DEVICE. ASME RATED TEMPERATURE & PRESSURE RELIEF VALVE. CONTINUOUS DUTY MOTOR W/ OVERLOAD PROTECTION. FLAME INSPECTION PORT DRAIN VALVE. ASME STAMPED FOR 160 PSI WORKING PRESSURE. 4" HAND HOLE DRAFT REGULATOR	U.L. LISTED TITLE 24 C.E.C. LISTED
WC 2	AMERICAN STANDARD ELONGATED WATER-SAVER "CADET" TOILET, MODEL NO. 2108.408 (FOR HANDICAPPED) VITREOUS CHINA. COLOR - WHITE	FURNISH COMPLETE WITH CLOSE-COUPLED TANK W/ WATER-SAVING TRIM, & BOLT CAPS, ANGLE SHUT-OFF VALVE, SUPPLY PIPE, OLSONITE WHITE SOLID PLASTIC OPEN FRONT SEAT #95	
HB 1	CHICAGO SILL FAUCET #998	3/4" FEMALE INLET, TEE HANDLE, VACUUM BREAKER, 3/4" HOSE THREAD, & DRAIN PLUG.	
SA 1	J.R. SMITH HYDROTROL ARRESTER # 5010		
SA 2	J.R. SMITH HYDROTROL ARRESTER # 5225		

LEGEND	
	SHEET METAL DUCT
	OPPOSED BLADE VOLUME DAMPER
	SINGLE LINE DUCT
	90° ELBOW WITH TURNING VANE
	CEILING SUPPLY DIFFUSER
	CEILING RETURN REGISTER
	CONNECT TO EXISTING
	EXISTING
	HEATING / VENTILATING UNIT
	CEILING DIFFUSER
	CEILING RETURN
	REMOVE EXISTING PIPE OR EQUIPMENT
	WASTE / SOIL
	VENT
	COLD WATER
	HOT WATER
	GAS
	CONNECT TO EXISTING FLOOR DRAIN
	WATER CLOSET
	URINAL
	LAVATORY
	SERVICE SINK
	SHOWER
	FLOOR DRAIN
	WATER HEATER
	WASH SINK
	SOAP TANK
	SHOCK ABSORBER

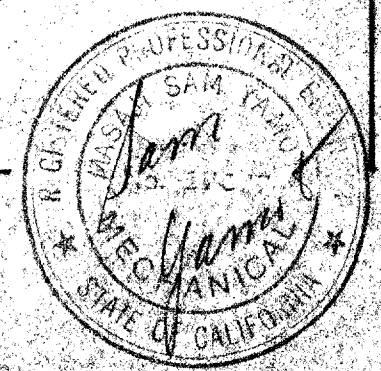

REVISIONS

metamorphosis

ARCHITECTURE & CONSTRUCTION

1000 TELEGRAPH BLVD., SUITE 200, OAKLAND, CA 94612

PH 415.774.1111 FAX 415.774.1112

PLUMBING FLOOR PLAN AND FIXTURE SCHEDULES

ASSEMBLY BUILDING REMODEL

CITY OF BERKELEY CORPORATION YARD

1326 Allston Way, Berkeley, California

DRAWN

CHECKED

DATE 12-6-85


SCALE 1/4" = 1'-0"

JOB NO. 8515

SHEET

9

OF 14 SHEETS

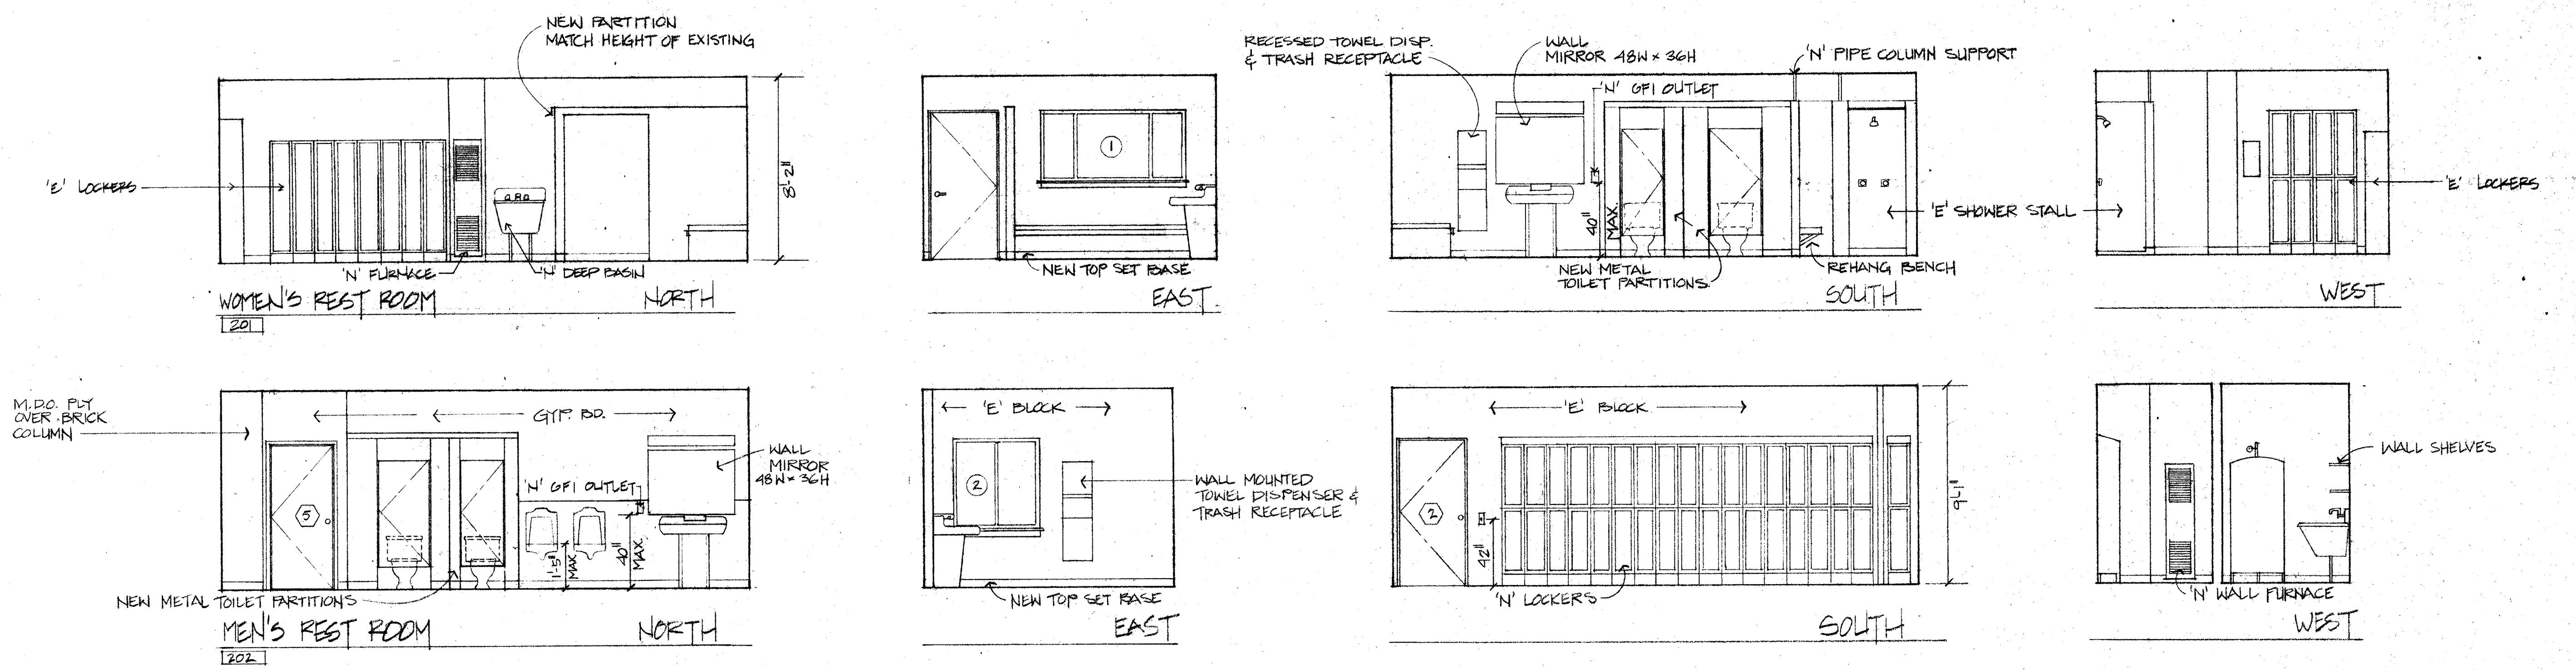

FINISH SCHEDULE						
NO.	NAME	FLOOR	WALLS	CEILING	BASE	REMARKS
201	WOMEN'S RESTROOM	N VINYL SHEET FLOOR	N-GYP BOARD - REPAINT ALL WALLS	E' GYP BOARD REPAINT	N' TOP SET BASE	
202	MEN'S RESTROOM	"	"	N' GYP BOARD PAINT	"	GLASSBOARD PANELS AT URINALS/LAVS
203	ENTRY VESTIBULE	"	"	"	"	E' - NO WORK
204	JANITOR	N VINYL SHEET FLOORING	N-GYP BOARD - REPAINT ALL WALLS	N' GYP BOARD PAINT	N' TOP SET BASE	
NOTES: INFILL FLOOR AT SHOWER STALL & URINALS AS PER DETAILS $\frac{F}{3}$ & $\frac{A}{3}$						

LIGHTING FIXTURE SCHEDULE					
TYPE	DESCRIPTION	CATALOG NUMBER	MOUNTING	LAMPS	REMARKS
A	2'x4'x2 LAMP FLUOR. FIX W/OPAL ACRYLIC DROP BOWL DIFF.	WELLMAN #325-SOP-A18RS	CEILING RECESSED LATCH	4-FAORS	
B	ROUND INCANDESCENT DOWN LIGHT W/DROP OPAL PLASTIC LENS	HALO H-7 HOUSING & TIAC TRIM	CEILING RECESSED	1-60W A19	SHOWEELIGHT, FINISH - "P" SATIN WHITE
C	INCANDESCENT LAMP HOLDER	BRYANT 522B KEYLESS	CEILING SURFACE	1-100W	
D	"WALL LIGHTER"	GENERAL ELECTRIC C583N506	EXTERIOR WALL SURFACE	HP870W	
E	2 LAMP FLUOR. FIX. WITH FLAT OPAL ACRYLIC DIFFUSER, PAKED WHITE BLANKE FINISH.	WELLMAN ESAD-24BRSHPF	WALL SURFACE	2-FAOW	

DOOR SCHEDULE						
NO.	THICKNESS	SIZE	TYPE	HARDWARE GROUP	REMARKS	FRAMES
1	"	"	"	8	REVERSE DOOR SWING, N' LEVER HARDWARE, ACCESS SIGNAGE, REPAINT	"
2	"	"	"	9	E' - N' LEVER HARDWARE, ACCESS SIGNAGE	"
3	"	"	"	10	E' " - N' LEVER HARDWARE ACCESS SIGNAGE	"
4	"	"	"	"	E' - NO WORK	"
5	1 1/2"	3'0" x 6'8"	SC WOOD PAINT GRADE	4	TOP & BOTTOM FIXED LOWERED VENTS	WOOD-FREHING
NOTES:						

REVISIONS

BY

metamorphosis

ARCHITECTURE & CONSTRUCTION

1000 CALIFORNIA STREET, SUITE 200

BERKELEY, CA 94704

510-841-2883

REGISTERED ARCHITECT

W. GOLZE

C-9284

STATE OF CALIFORNIA

INTERIOR

ELEVATIONS

AND

SCHEDULES

ASSEMBLY BUILDING REMODEL

CITY OF BERKELEY CORPORATION YARD

1326 Allston Way, Berkeley, California

DRAWN

D.V.

CHECKED

P.G.

DATE

12-6-83

SCALE

AS NOTED

JOB NO.




8515

SHEET


12

OF 14 SHEETS

EQUIPMENT SCHEDULE	
SYMB.	DESCRIPTION
HV	JACKSON/CHURCH ROOF TOP HEATING & VENTILATING UNIT, MODEL # RT-2000, WT. 350 LBS. BURNER: 200 M.B.H. INPUT, 150 M.B.H. OUTPUT, SPARK IGNITION FAN: 2600 C.F.M. AT .3" S.P., 1/2 HP MOTOR, 120V/1 ϕ FILTER: (2) 16"X20"X2", (2) 20"X20"X2" CONTROL: BY TIME CLOCK
HV	JACKSON/CHURCH ROOF TOP HEATING & VENTILATING UNIT, MODEL # RT-1000, WT. 250 LBS. BURNER: 100 M.B.H. INPUT, 75 M.B.H. OUTPUT, SPARK IGNITION FAN: 1425 C.F.M. AT .3" S.P., 1/3 HP MOTOR, 120V/1 ϕ FILTER: (2) 20"X25"X2" CONTROL: BY TIME CLOCK
WF	DAYTON GAS WALL FURNACE, 25 M.B.H. INPUT, 17.5 M.B.H. OUTPUT, REGULATED THERMOSTATIC VALVE WITH MODULATING CONTROL, STOCK NO. 3E289, SELF CONTAINED THERMOSTAT
EF	TRAWE UTILITY FAN, MODEL # 18FC, FORWARD CURVED BLADE, 2600 C.F.M. AT 3/8" S.P., 1/2 HP MOTOR, 120V/1 ϕ , 412 R.P.M., WT. 350 LBS., INTERLOCK WITH HV-1
EF 2	GREENHECK ROOF TOP EXHAUST FAN, MODEL # GB-9, 550 C.F.M. AT 1/8" S.P., 1055 R.P.M., DRIVE R-2, 1/4 HP MOTOR, 120V/1 ϕ , ROOF CURB & BACK DRAFT DAMPER, PROVIDE SWITCH INTERLOCK TO (E) LIGHT SWITCH.
AI	COOK SPIN ALUMINUM INTAKE VENTILATOR, MODEL TR-12 THROAT SIZE 12"X12", CAPACITY 511 C.F.M. AT .025" S.P. FINISH WITH BIRD SCREEN & ROOF CURB

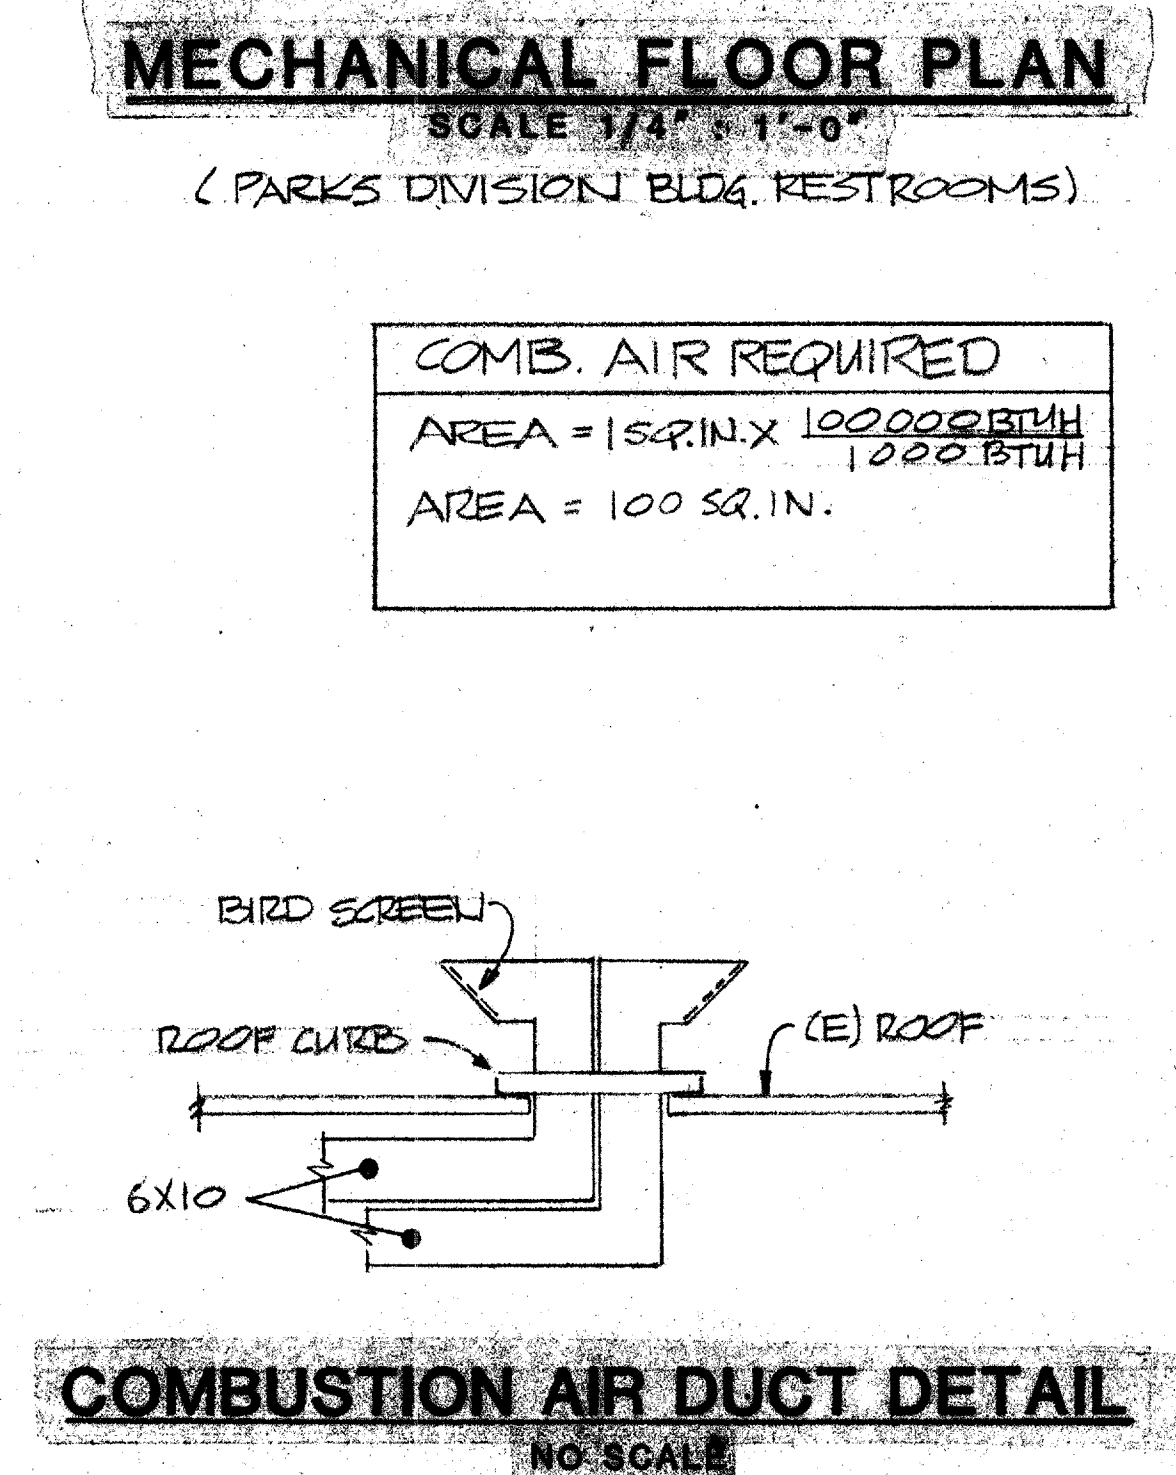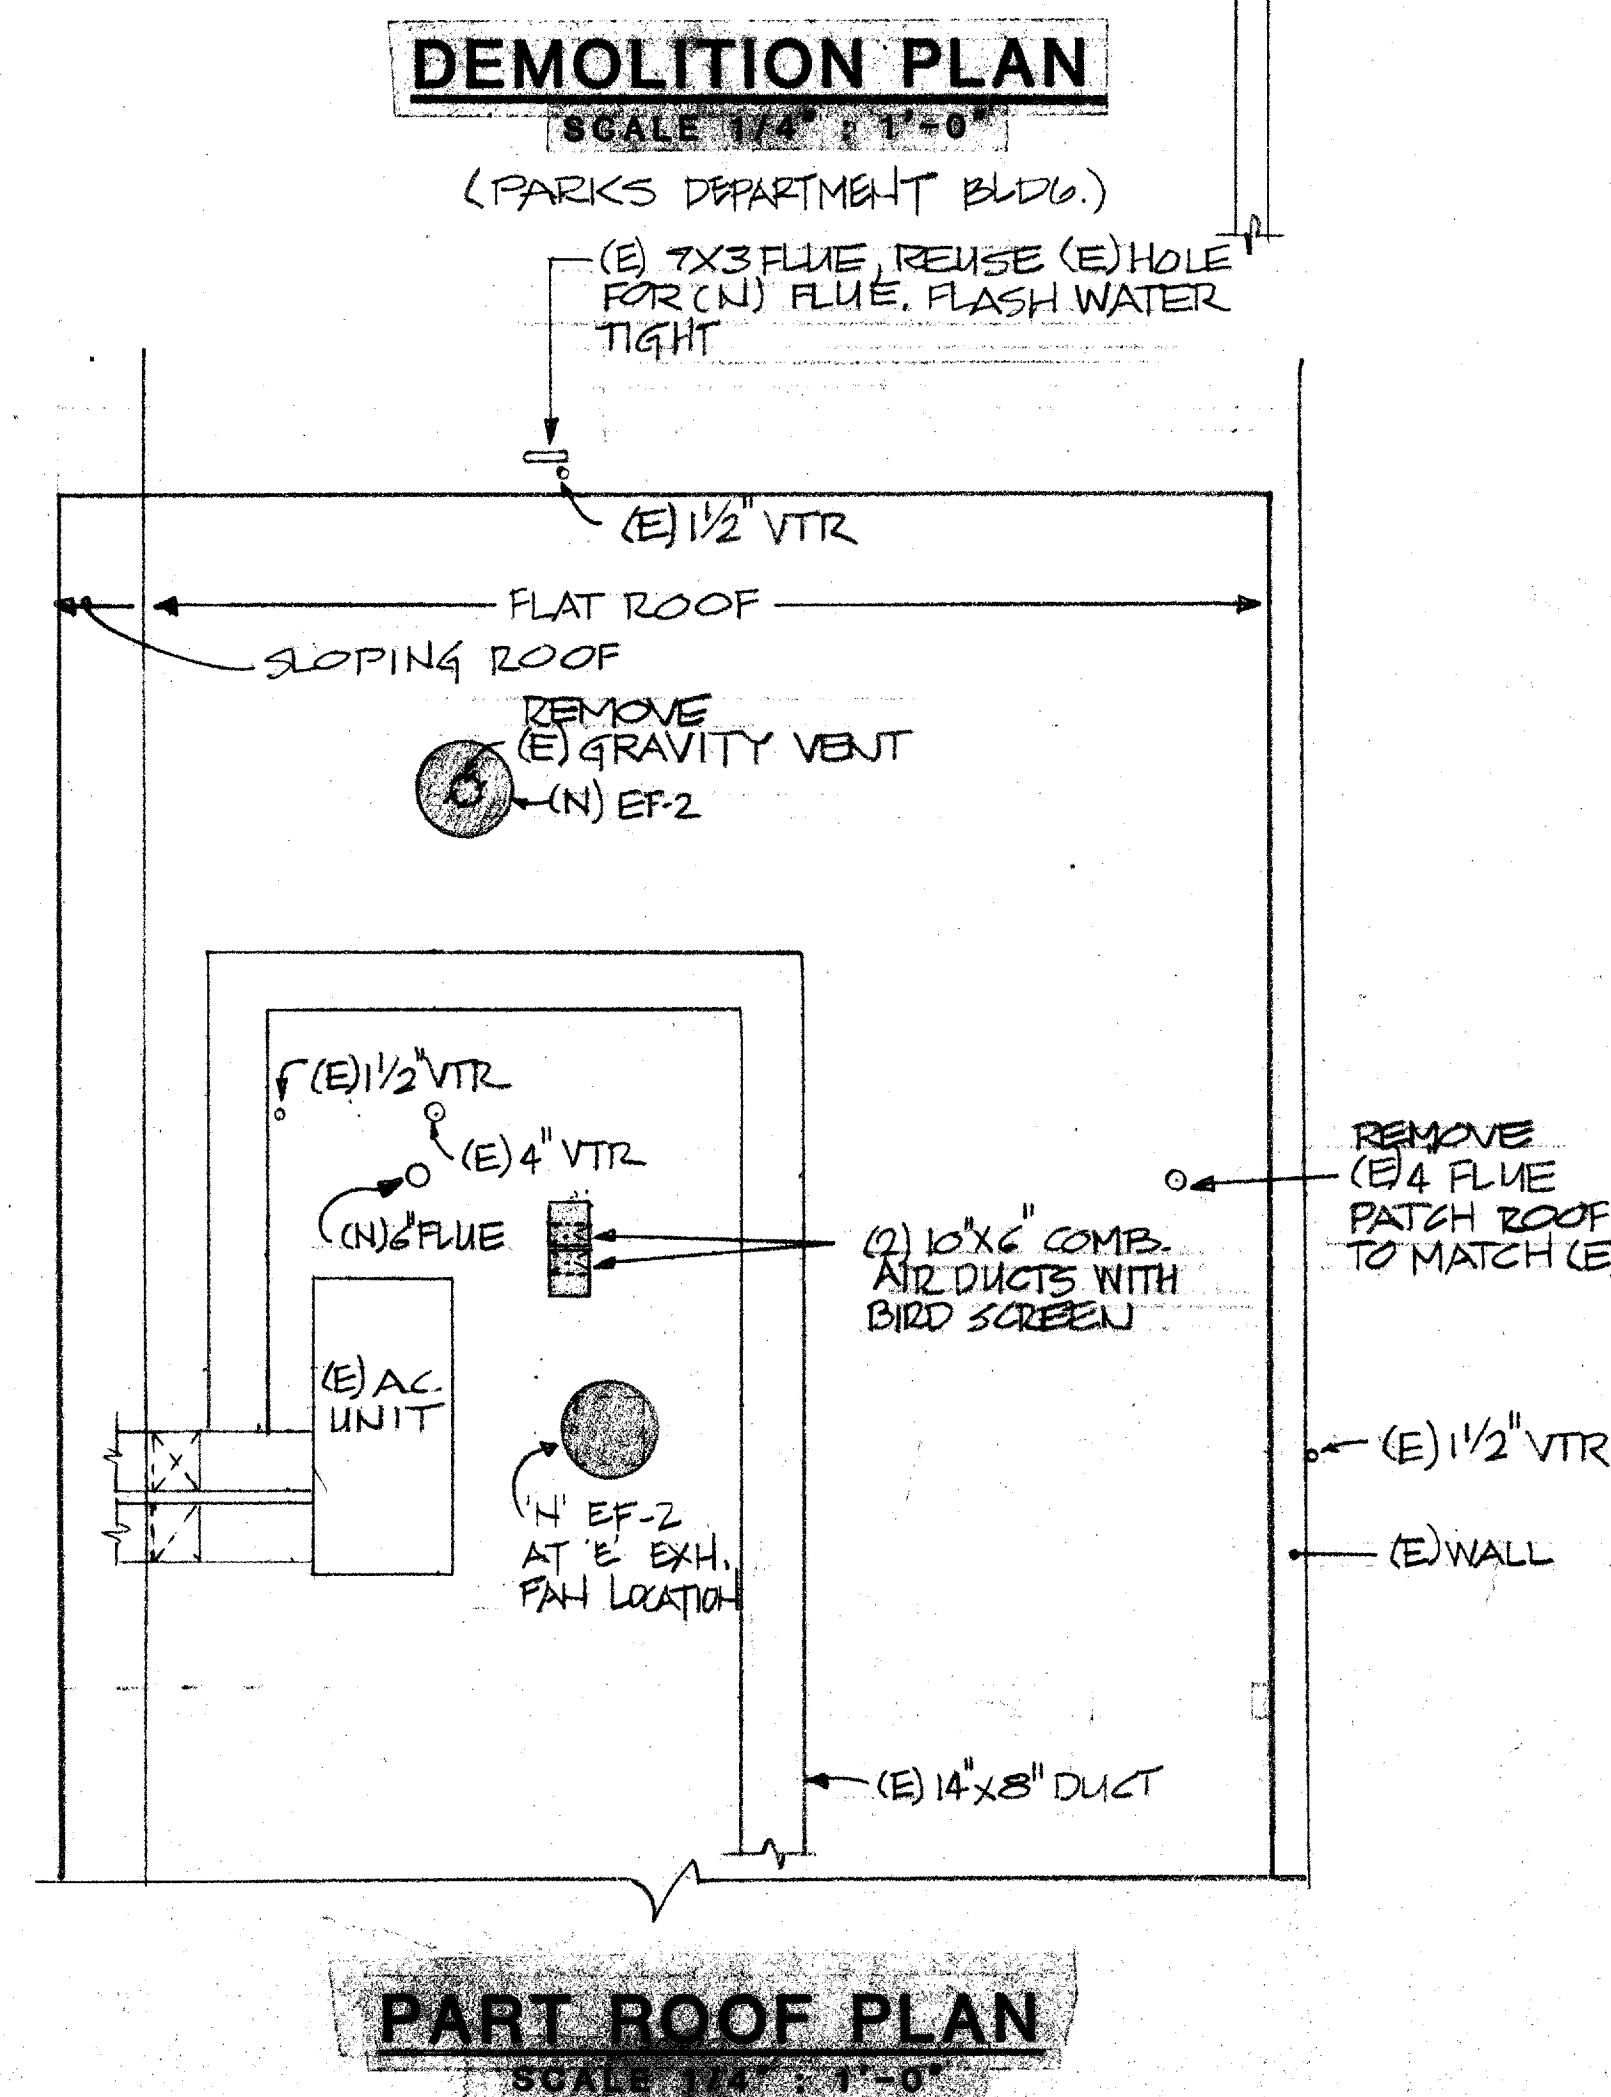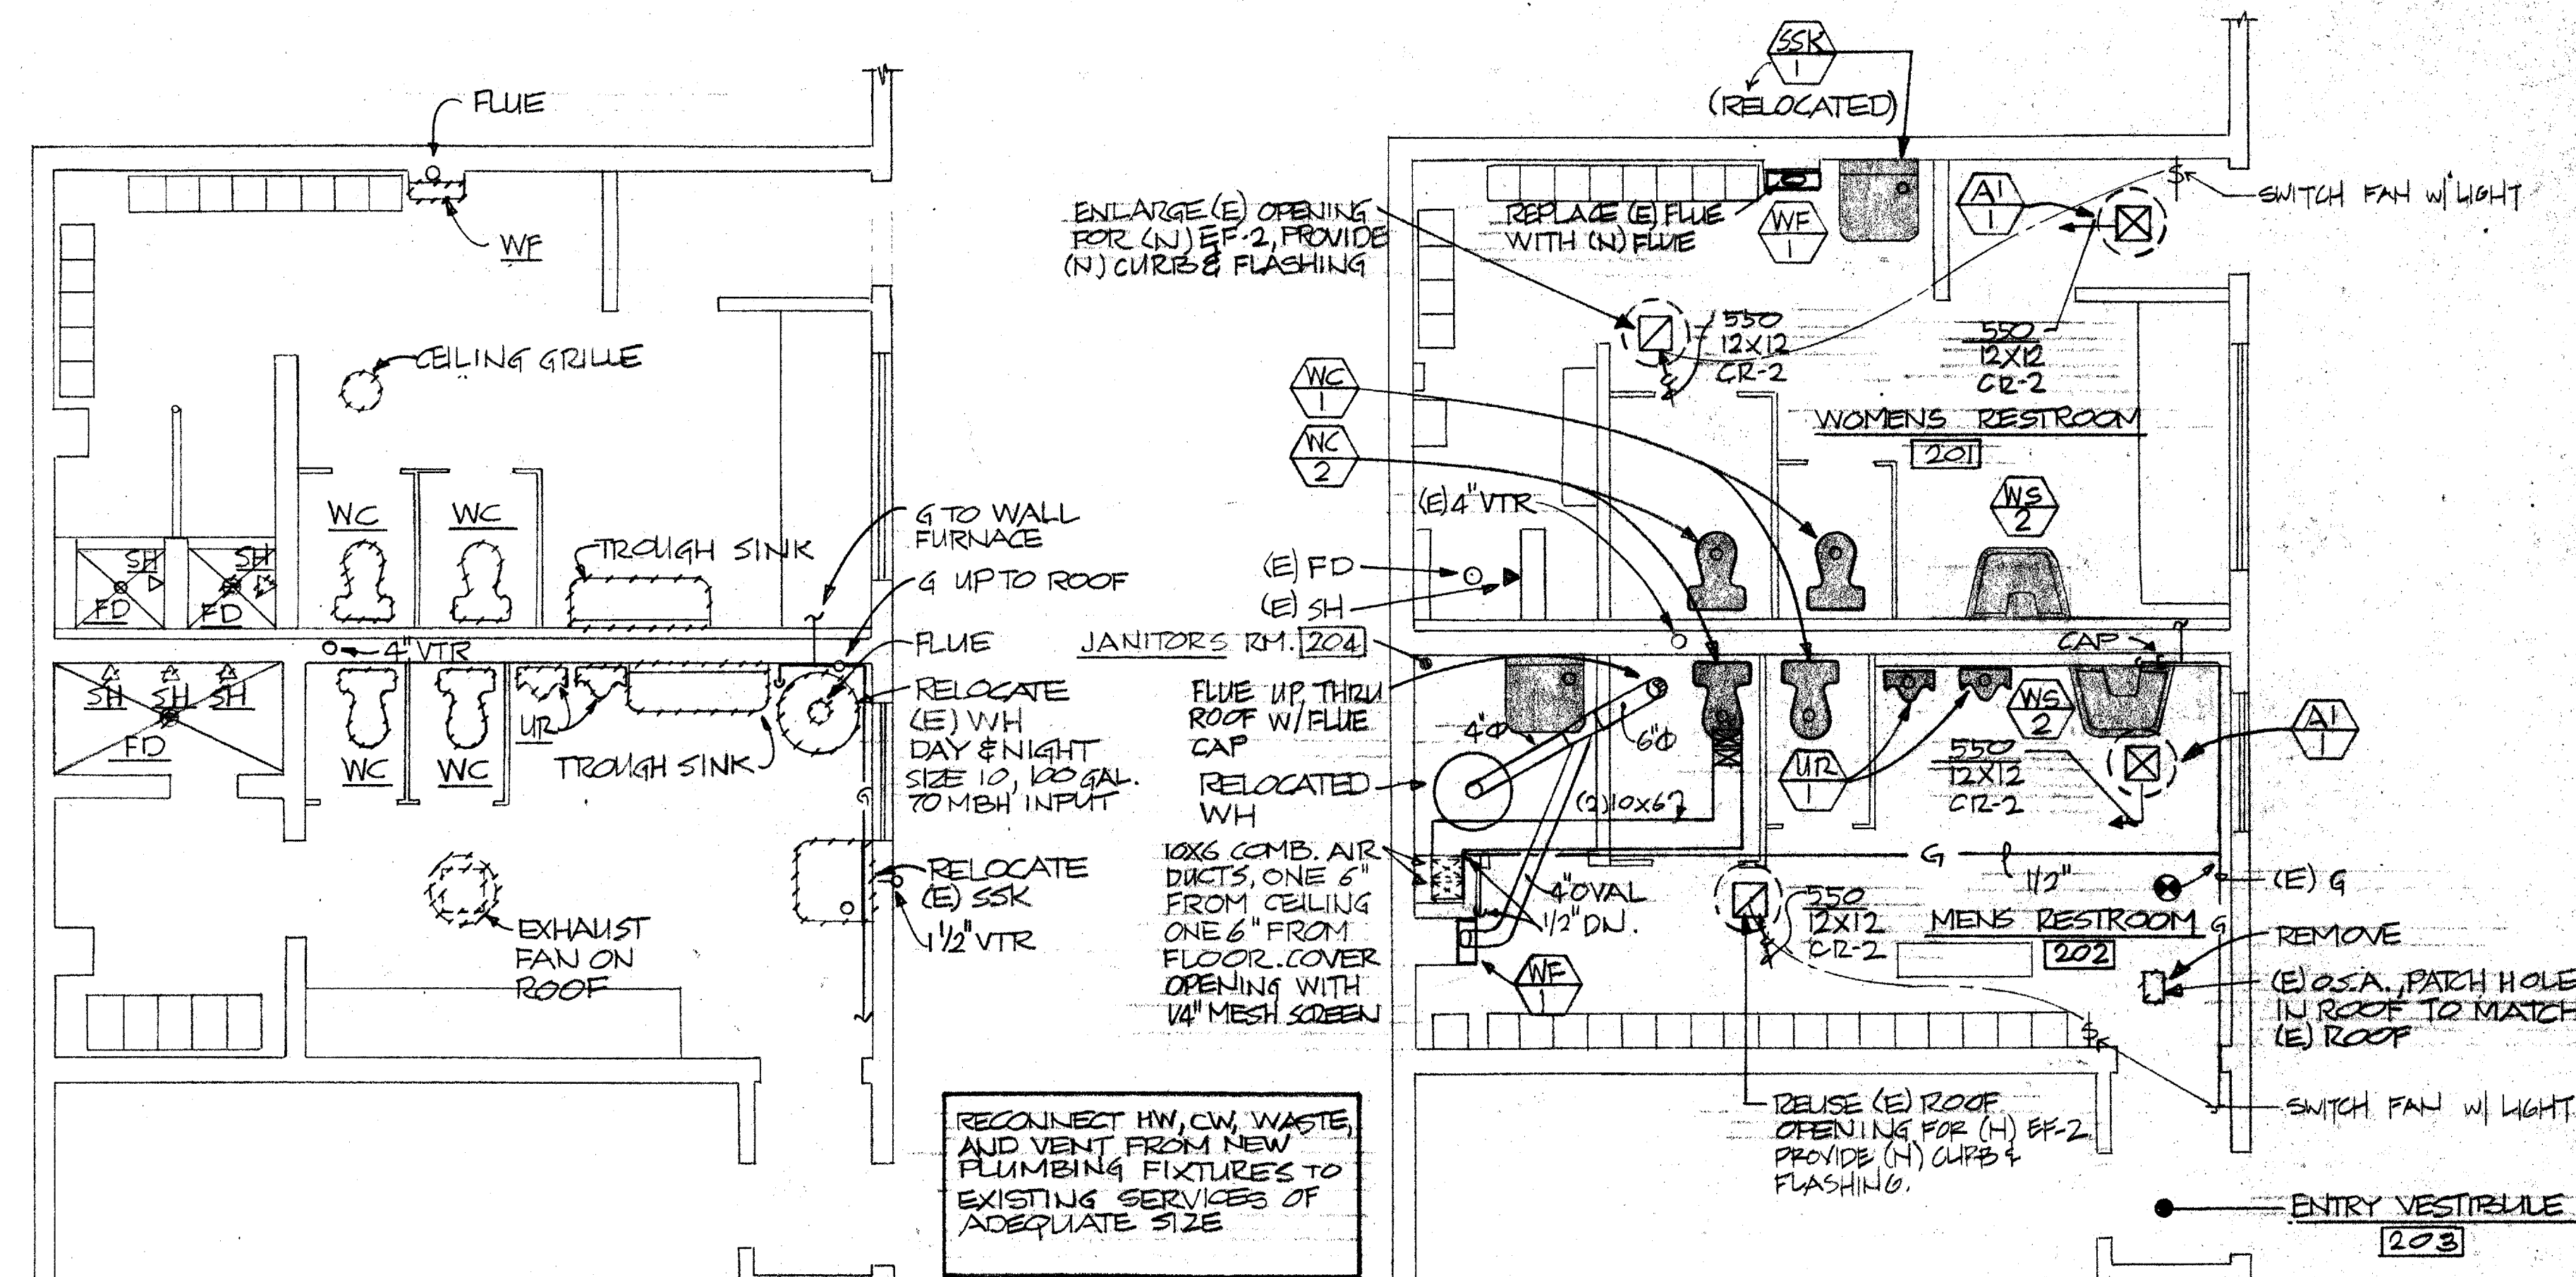


REVISIONS	BY

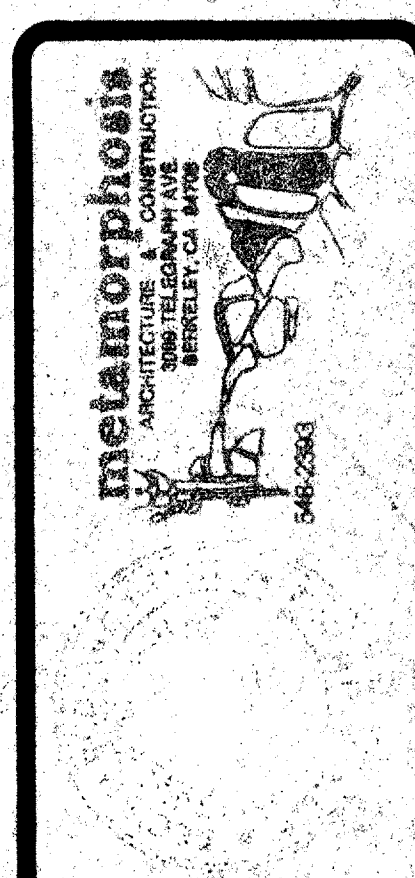





MECHANICAL FLOOR PLAN - PARKS DEPT BUILDING

ASSEMBLY BUILDING REMODEL
 CITY OF BERKELEY CORPORATION YARD
 1326 Allston Way, Berkeley, California

DRAWN	
CHECKED	
DATE	12-6-85
SCALE	1/4" = 1'-0"
JOB NO.	8515
SHEET	13
OF 14 SHEETS	

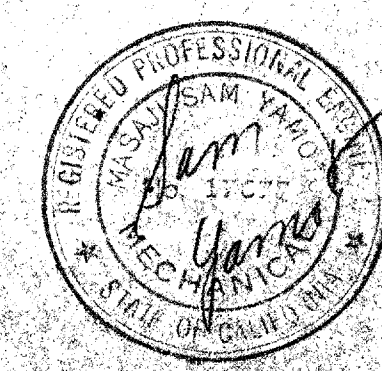


ALLSTON WAY

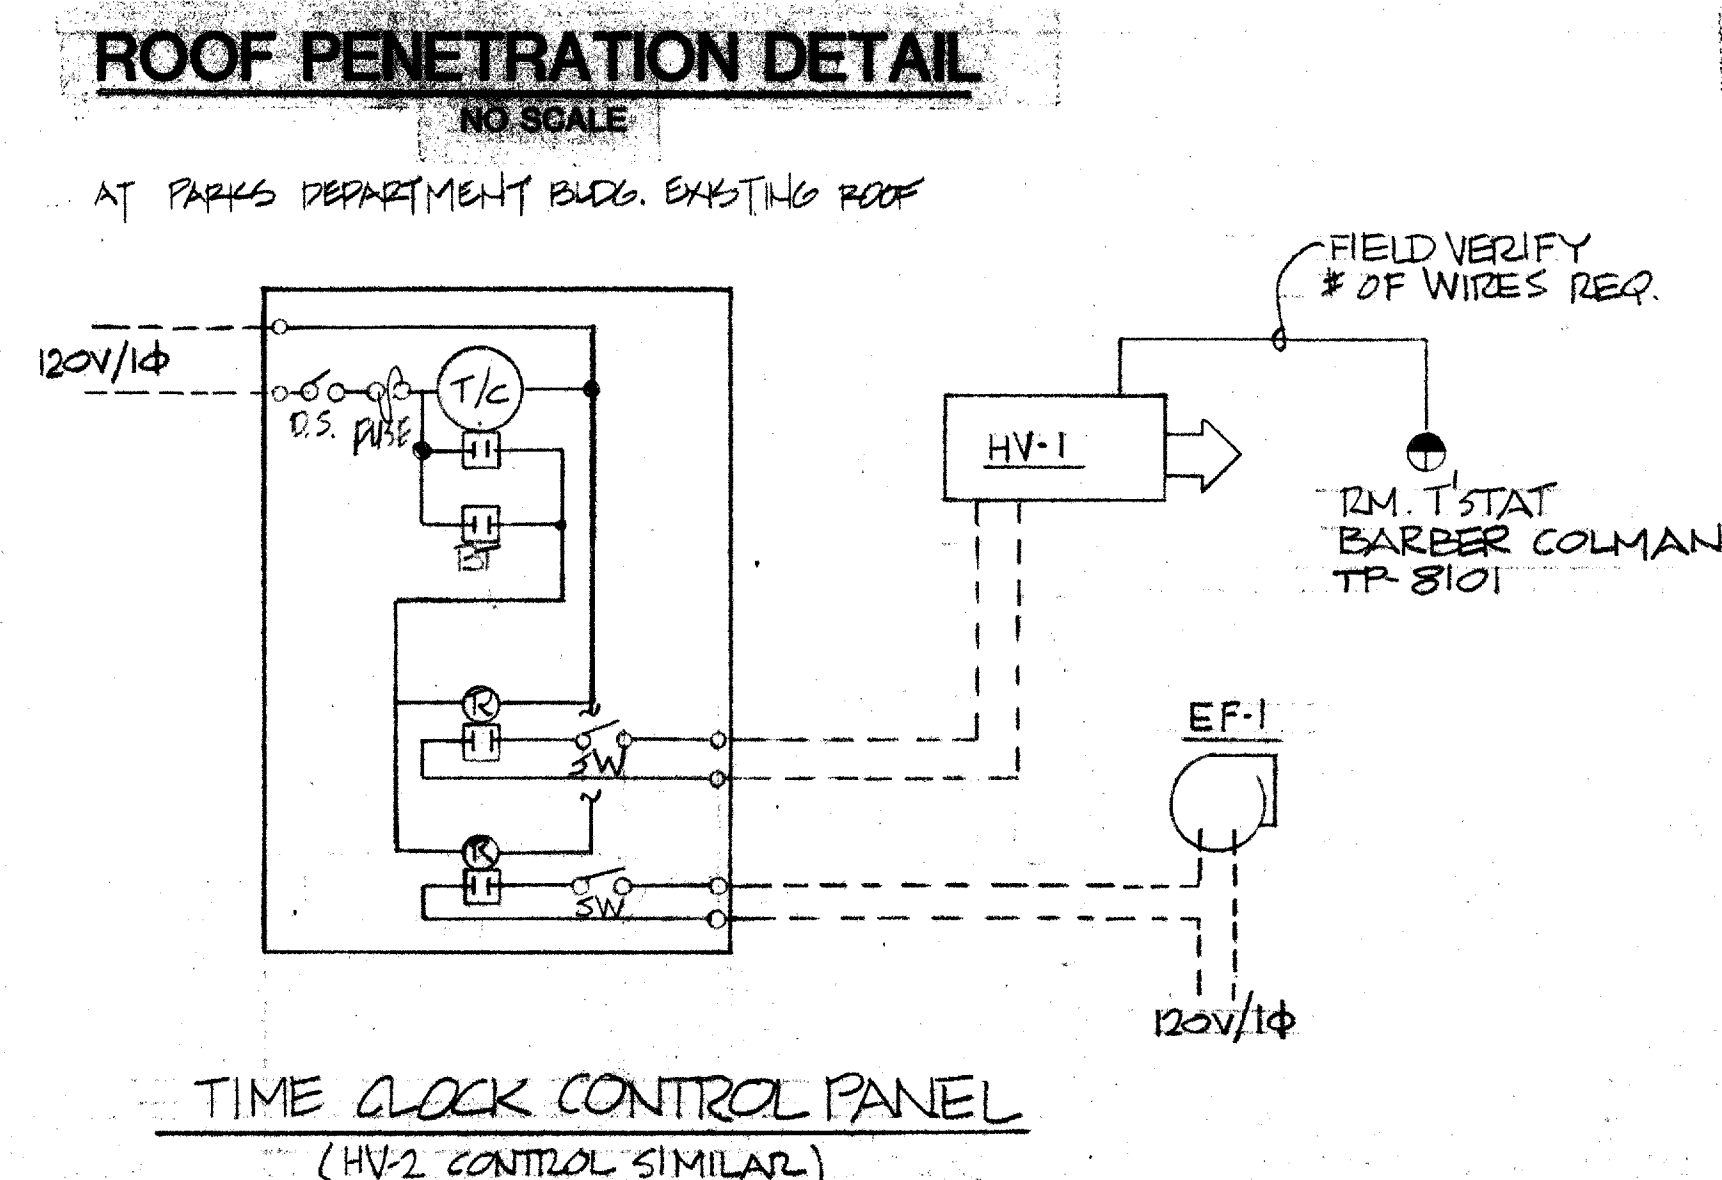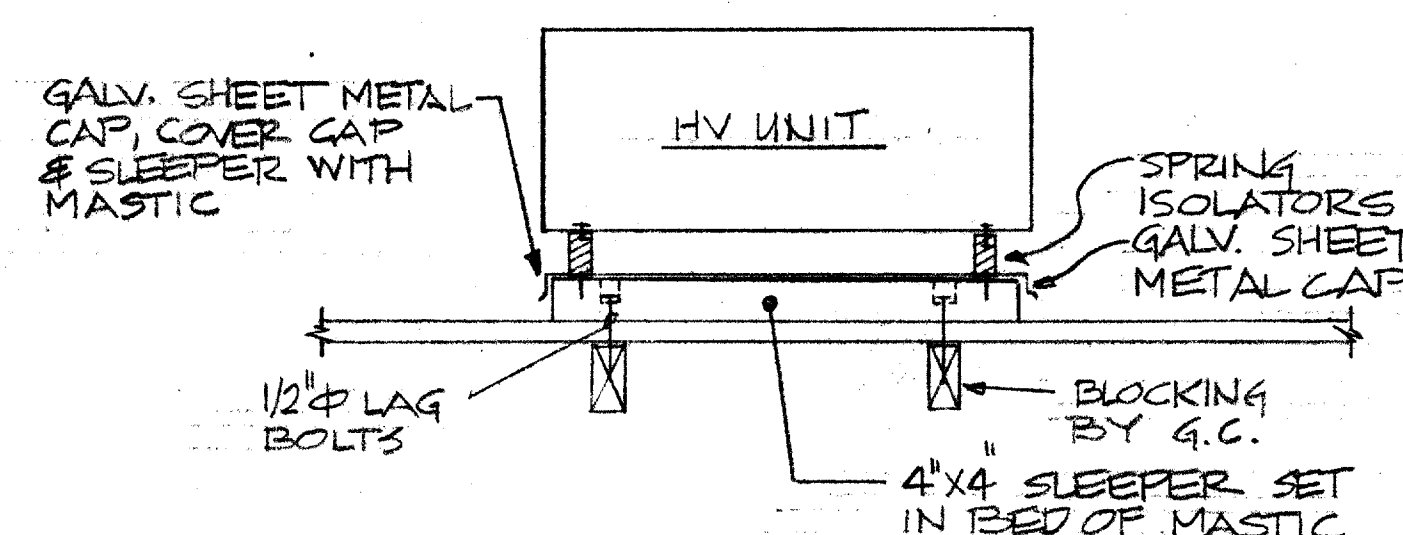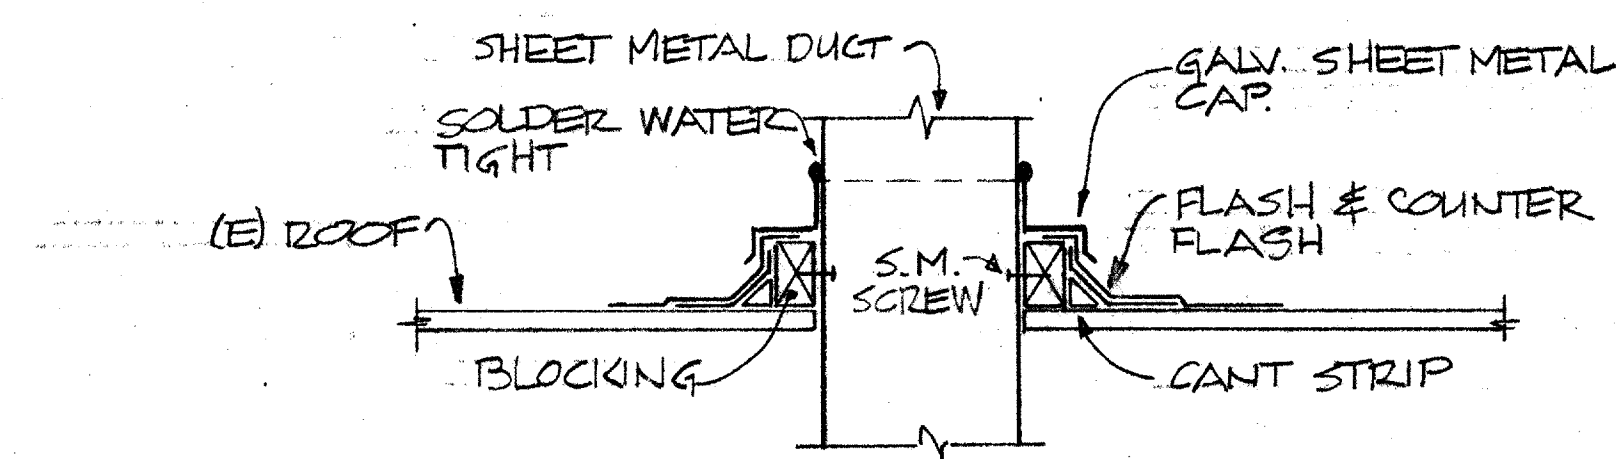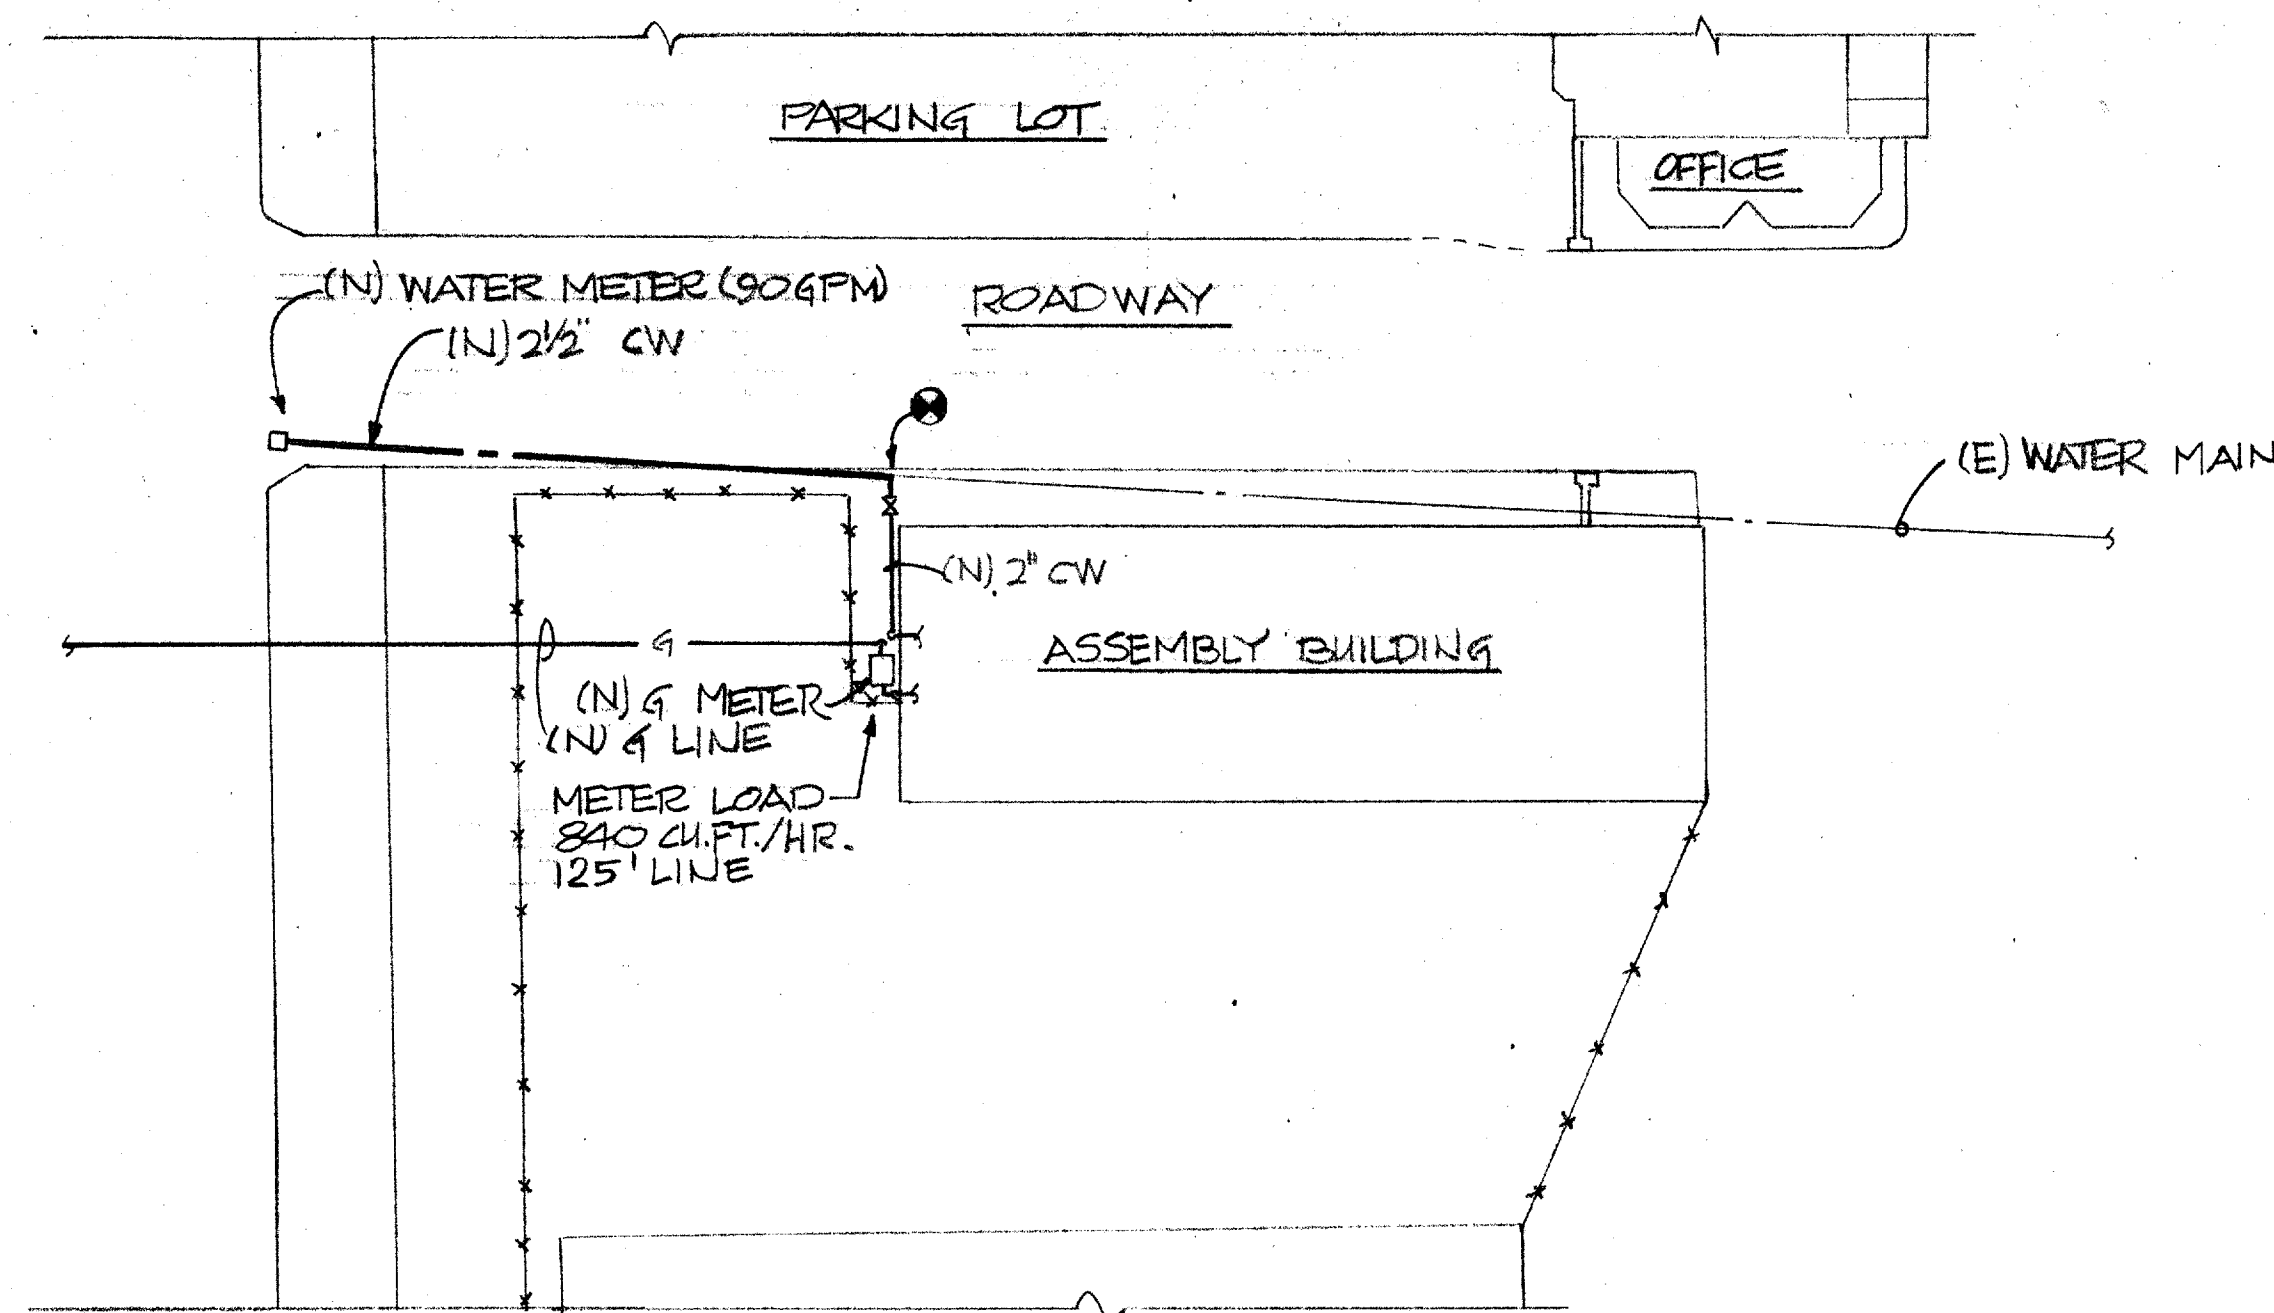

FIXTURE CONNECTION SCHEDULE					
SYMB.	DESCRIPTION	W/S	V	CW	HW
WC	WATER CLOSET	4"	2"	1/2"	—
UR	URINAL	2"	1 1/2"	3/4"	—
LV	LAVATORY	2"	1 1/2"	1/2"	1/2"
SSK	SERVICE SINK	3"	1 1/2"	3/4"	3/4"
WS	WASHFOUNTAIN ①	2"	1 1/2"	1"	1"
SH	SHOWER HEAD	—	—	1/2"	1/2"


AIR OUTLET SCHEDULE		
MARK	MANUFACTURER MODEL NO.	DESCRIPTION
CD-1	BARBER-COLMAN PSLV	PERFORATED FACE STEEL DIFFUSER FOR "T-BAR" INSTALLATION, OFF WHITE FINISH W/VOLUME DAMPER
CR-1	BARBER-COLMAN PELV	PERFORATED FACE STEEL RETURN REGISTER FOR "T-BAR" INSTALLATION, OFF-WHITE FINISH W/VOLUME DAMPER
CR-2	BARBER-COLMAN TXD	ALUMINUM SURFACE MOUNT EGG CRATE RETURN REGISTER W/1/2" X 1/2" LATTICE, VOLUME DAMPER
CD-2	BARBER-COLMAN SPSV	STEEL CONSTRUCTION LOWER FACE CEILING SUPPLY DIFFUSER WITH VOLUME DAMPER, OFF-WHITE FINISH

REVISIONS	BY

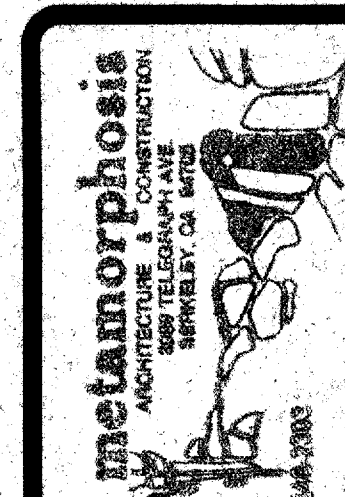

FIXTURE SCHEDULES

ASSEMBLY BUILDING REMODEL
CITY OF BERKELEY CORPORATION YARD
1326 Allston Way, Berkeley, California

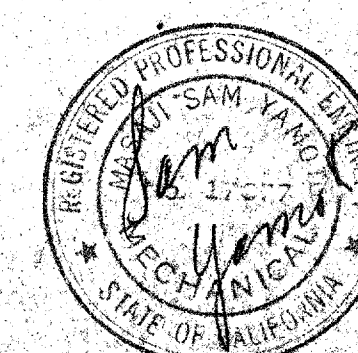

DRAWN
CHECKED
DATE 12-6-85
SCALE 1"
JOB NO. 8515
SHEET 14
OF 14 SHEETS